


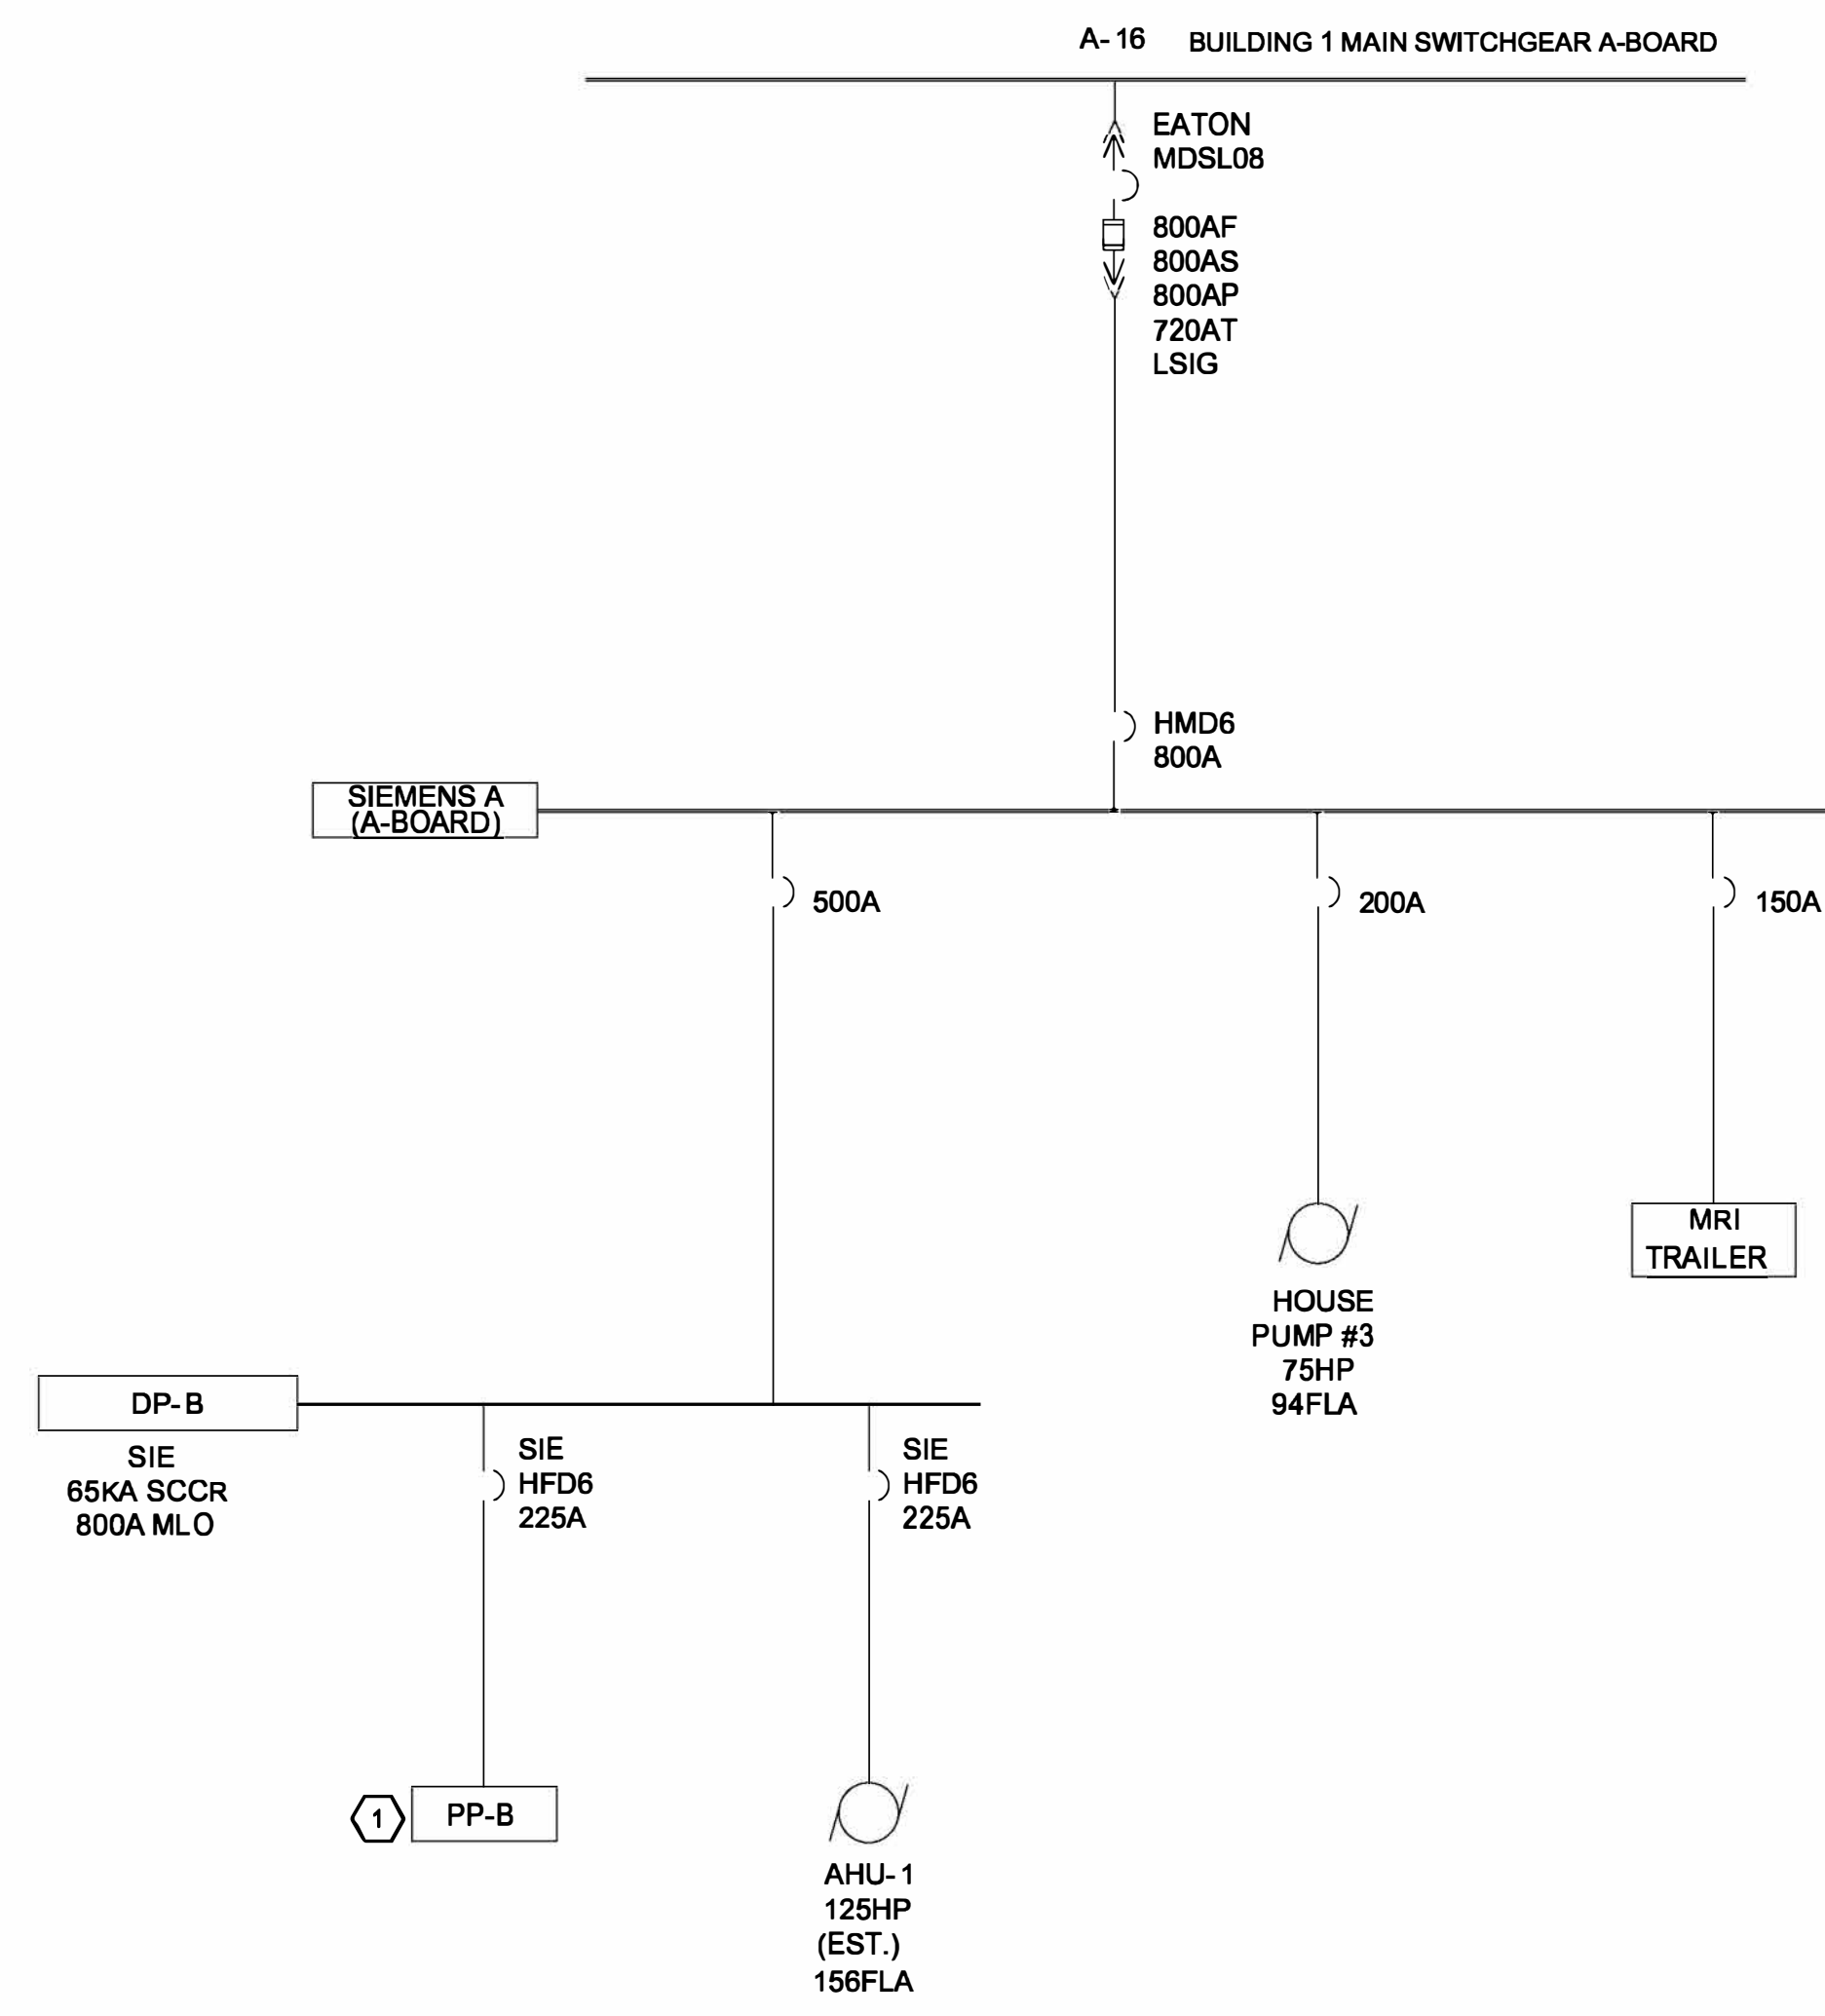

ONE-LINE DIAGRAM NOTES:

1. NOT ALL CIRCUITS ARE SHOWN ON ONE-LINE DIAGRAM. SEE PANEL SCHEDULE THIS DRAWING.

PANEL SCHEDULE

POWER PANEL

PP-B

LOCATION XFMR ROOM B-401

INSTALLATION SURFACE

RATINGS

225A

AMPS

480Y/277V

VOLTS

3

PH

4

WIRE, 60

HZ

GRD BAR

YES

MAIN LUGS

-

CB. INTERRUPTING RATING

65KAIC

RMS. SYMM. AMPS

MAIN CIRCUIT BREAKER

225A

AMPS

CONNECTED LOAD


-

KW,

PANEL SIZE

42 SPACES


DESCRIPTION	LOAD W/KV/HP	CB AMPS	CIR	A	B	C	CIR	CB AMPS	LOAD W/KV/HP	DESCRIPTION
UNIDENTIFIED (ON)		20	1	→	→	→	2	20		UNIDENTIFIED (ON)
UNIDENTIFIED (ON)		20	3	→	→	→	4	20		UNIDENTIFIED (ON)
UNIDENTIFIED (ON)		20	5	→	→	→	6	20		UNIDENTIFIED (ON)
UNIDENTIFIED (ON)		20	7	→	→	→	8	20		UNIDENTIFIED (ON)
UNIDENTIFIED (ON)		20	9	→	→	→	10	20		UNIDENTIFIED (ON)
UNIDENTIFIED (ON)		20	11	→	→	→	12	20		UNIDENTIFIED (ON)
		13	15	→	→	→	14			
UNIDENTIFIED (ON)		15	17	→	→	→	15			UNIDENTIFIED (ON)
		19	19	→	→	→	16			
HOT WATER CIRC PUMP		15	21	→	→	→	15			TB BATHROOM EXHAUST ADMITTING
		23	23	→	→	→	17			
EXHAUST FAN EF-1		20	25	→	→	→	26			BACK-UP HOT WATER CIRC PUMP (OFF)
		20	27	→	→	→	28	20		
		29	29	→	→	→	29			
EX-HAUST FAN GX-1		30	31	→	→	→	32			SPACE
		33	33	→	→	→	34			SPACE
		35	35	→	→	→	36			SPACE
SPACE		37	37	→	→	→	38			SPACE
SPACE		39	39	→	→	→	40			SPACE
SPACE		41	41	→	→	→	42			SPACE

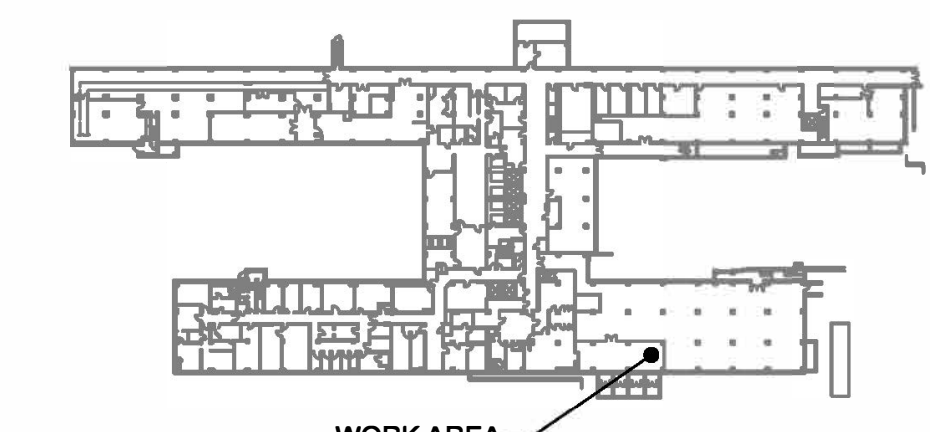


B1 - BASEMENT - KEY PLAN
NOT TO SCALE

A1 PARTIAL BUILDING 1 BASEMENT FLOOR PLAN


- | | |
|---|---|
| <p><u>DRAWING NOTES:</u></p> <ol style="list-style-type: none"> 1. WORK SHOWN THIS DRAWING SHALL TAKE PLACE DURING AN EVENING/NIGHT WEEKEND SHIFT. | <p><u>DRAWING KEYNOTES:</u> </p> <ol style="list-style-type: none"> 1. DE-ENERGIZE, DISCONNECT, REMOVE AND REPLACE SURFACE MOUNTED PANEL INDICATED. DISCONNECT FEEDER AND BRANCH CIRCUIT CONDUCTORS TO FACILITATE PANEL REPLACEMENT. PROVIDE ALL MATERIAL AND LABOR TO TERMINATE FEEDER AND BRANCH CIRCUIT CONDUCTORS TO REPLACEMENT PANEL INCLUDING ANY REQUIRED CABLE EXTENSIONS. REFER TO PANEL SCHEDULE THIS DRAWING. PANEL AND CIRCUIT BREAKERS SHALL MEET/EXCEED SHORT CIRCUIT CURRENT RATING INDICATED IN PANEL SCHEDULE |
|---|---|

 		CONSULTANTS:		STAMP		ARCHITECT/ENGINEERS:		APPROVED BY: VJC		DATE: 08/24/22		Drawing Title		Project Title		Project Number		Office of Construction and Facilities Management	
		 RAMBOLL RAMBOLL AMERICAS ENGINEERING SOLUTIONS, INC. 18 LINK DRIVE BINGHAMTON, NY 13902		 2022-08-17		 259 St. Ives Dr. Talent, OR 97540		TASK ORDER 5 PANEL PP-B AREA PLAN ONE-LINE DIAGRAM AND SCHEDULE Approved: Project Director		UPGRADE LIFE SAFETY/CRITICAL BRANCH ELECTRICAL DISTRIBUTION NY HARBOR HEALTHCARE CENTER VA BROOKLYN CAMPUS		630A4-16-430		Building Number 1 Drawing Number 18-01-BK EP-158 Dwg. 63 of 91					
REV. 0 ISSUED FOR CONSTRUCTION Revisions:										08/24/22 Date		Location 800 POLY PLACE, BROOKLYN NY 11209				Issue Date 08/24/22			

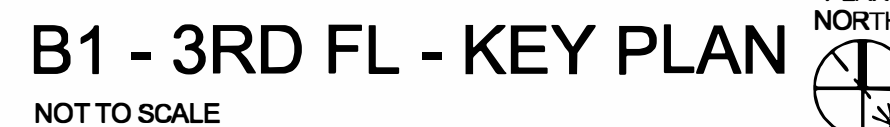

three inches = one foot
one and one half inches = one foot
one inch = one foot
three quarters inch = one foot
one half inch = one foot
three eighths inch = one foot
one quarter inch = one foot
one eighth inch = one foot

A
B
C
D
E
F

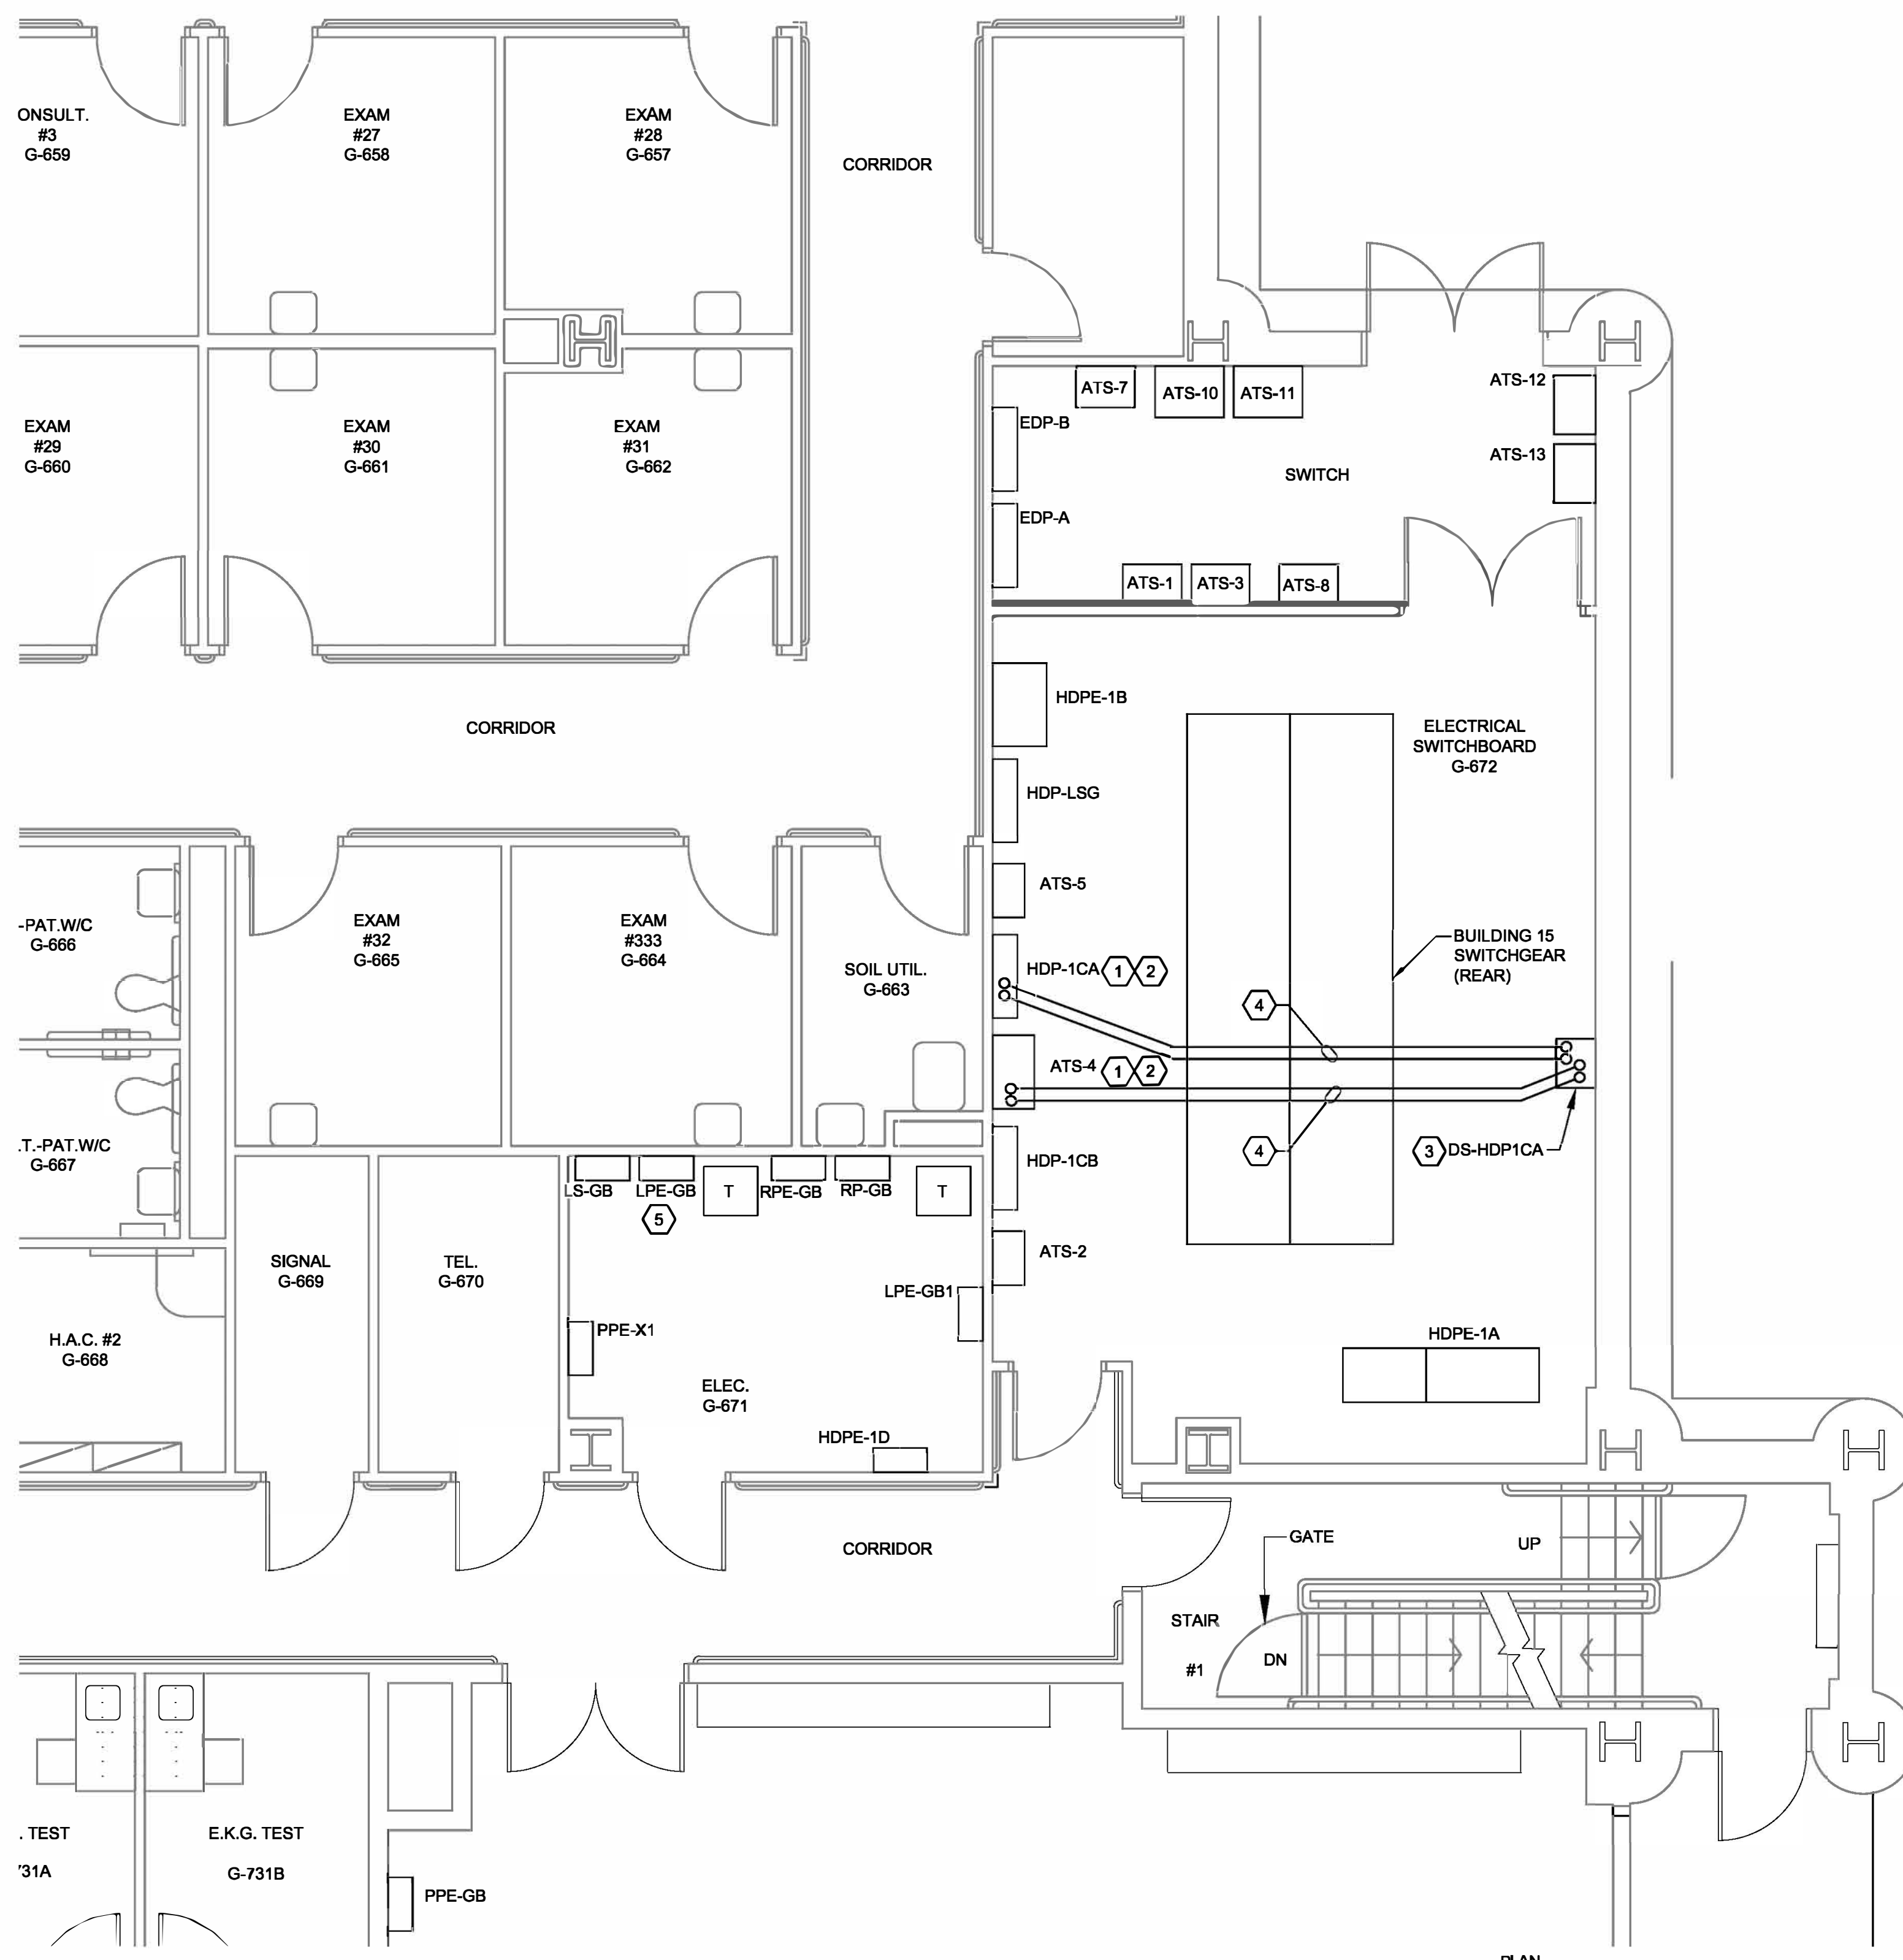


A1 PARTIAL BUILDING 15 GROUND FLOOR PLAN
1/4"=1'-0"
4' 2' 0' 2' 4'

- DRAWING NOTES:**
- WORK SHOWN THIS DRAWING SHALL TAKE PLACE ON NIGHT/WEEKEND SHIFTS.
 - DISCONNECT SWITCH, ASSOCIATED RACEWAY AND CABLE SHALL BE INSTALLED TO THE FURTHEST EXTENT POSSIBLE PRIOR TO SHUTDOWN OF ATS-4 AND PANEL HDP-1CA. SHUTDOWN FOR ELECTRICAL DEMOLITION AND TERMINATIONS SHALL TAKE PLACE ON AN EVENING/NIGHT WEEKEND SHIFT.
- DRAWING KEYNOTES: (#)**
- DE-ENERGIZE, DISCONNECT, AND REMOVE POWER CIRCUIT FROM ATS-4 TO PANEL HDP-1CA AS INDICATED COMPLETE.
 - PROVIDE ALL MATERIAL AND LABOR TO TIE INTO EXISTING ELECTRICAL EQUIPMENT INDICATED.
 - PROVIDE A SURFACE MOUNTED, 600V, 3-POLE, 600A, FUSED DISCONNECT SWITCH WITH NEUTRAL BAR AS INDICATED WITH 200KAIC RATED VERY FAST ACTING CURRENT LIMITING FUSES AS INDICATED IN NEMA 12 LOCKABLE ENCLOSURE.
 - PROVIDE POWER CIRCUIT AS INDICATED.
 - DE-ENERGIZE, DISCONNECT, REMOVE AND REPLACE SURFACE MOUNTED PANEL INDICATED. DISCONNECT FEEDER AND BRANCH CIRCUIT CONDUCTORS TO FACILITATE PANEL REPLACEMENT. PROVIDE ALL MATERIAL AND LABOR TO TERMINATE FEEDER AND BRANCH CIRCUIT CONDUCTORS TO REPLACEMENT PANEL INCLUDING ANY REQUIRED CABLE EXTENSIONS. REFER TO PANEL SCHEDULE THIS DRAWING. PANEL AND CIRCUIT BREAKERS SHALL MEET/EXCEED SHORT CIRCUIT CURRENT RATING INDICATED IN PANEL SCHEDULE.


PANEL SCHEDULE									
POWER PANEL	LPE-GB	LOCATION	ELEC CLOSET G-671	INSTALLATION	SURFACE				
RATINGS	125A	AMPS	480Y/277V	VOLTS	3 PH	4	WIRE	60	HZ
MAIN LUGS			CB INTERRUPTING RATING	65KAIC	RMS	SYM. AMPS			
MAIN CIRCUIT BREAKER	90A	AMPS	CONNECTED LOAD		KW	PANEL SIZE	30	SPACES	
DESCRIPTION	LOAD	CB	CIR	ABC	CIR	CB	LOAD	DESCRIPTION	
169A, 169, 168, 167, G.F.S.	20	1	→	→	2	20	111, 11A, 11B, 127, G.F.S.		
131, 134, 150, GND FL STH	20	3	→	→	4	20	SPARE (ON)		
G.F.S. INTER	20	5	→	→	6				
EM BATT. PAK-ROOMS GB169A	20	7	→	→	8	60	RPE-GB VIA T5		
SPARE (ON)	20	9	→	→	10				
SPARE (ON)	20	11	→	→	12	20	SPARE (ON)		
SPARE (ON)	20	13	→	→	14	20	SPARE (ON)		
SPARE (ON)	20	15	→	→	16	20	SPARE (ON)		
SPARE (ON)	20	17	→	→	18	20	SPARE (ON)		
SPACE	19						SPACE		
SPACE	21						SPACE		
SPACE	23						SPACE		
SPACE	25						SPACE		
SPACE	27						SPACE		
SPACE	29						SPACE		

A5 PARTIAL BUILDING 15 ONE-LINE DIAGRAM
NOT TO SCALE

- ONE-LINE DIAGRAM NOTES:**
- NOT ALL BRANCH/FEEDER CIRCUITS ARE NOT SHOWN ON ONE-LINE DIAGRAM.

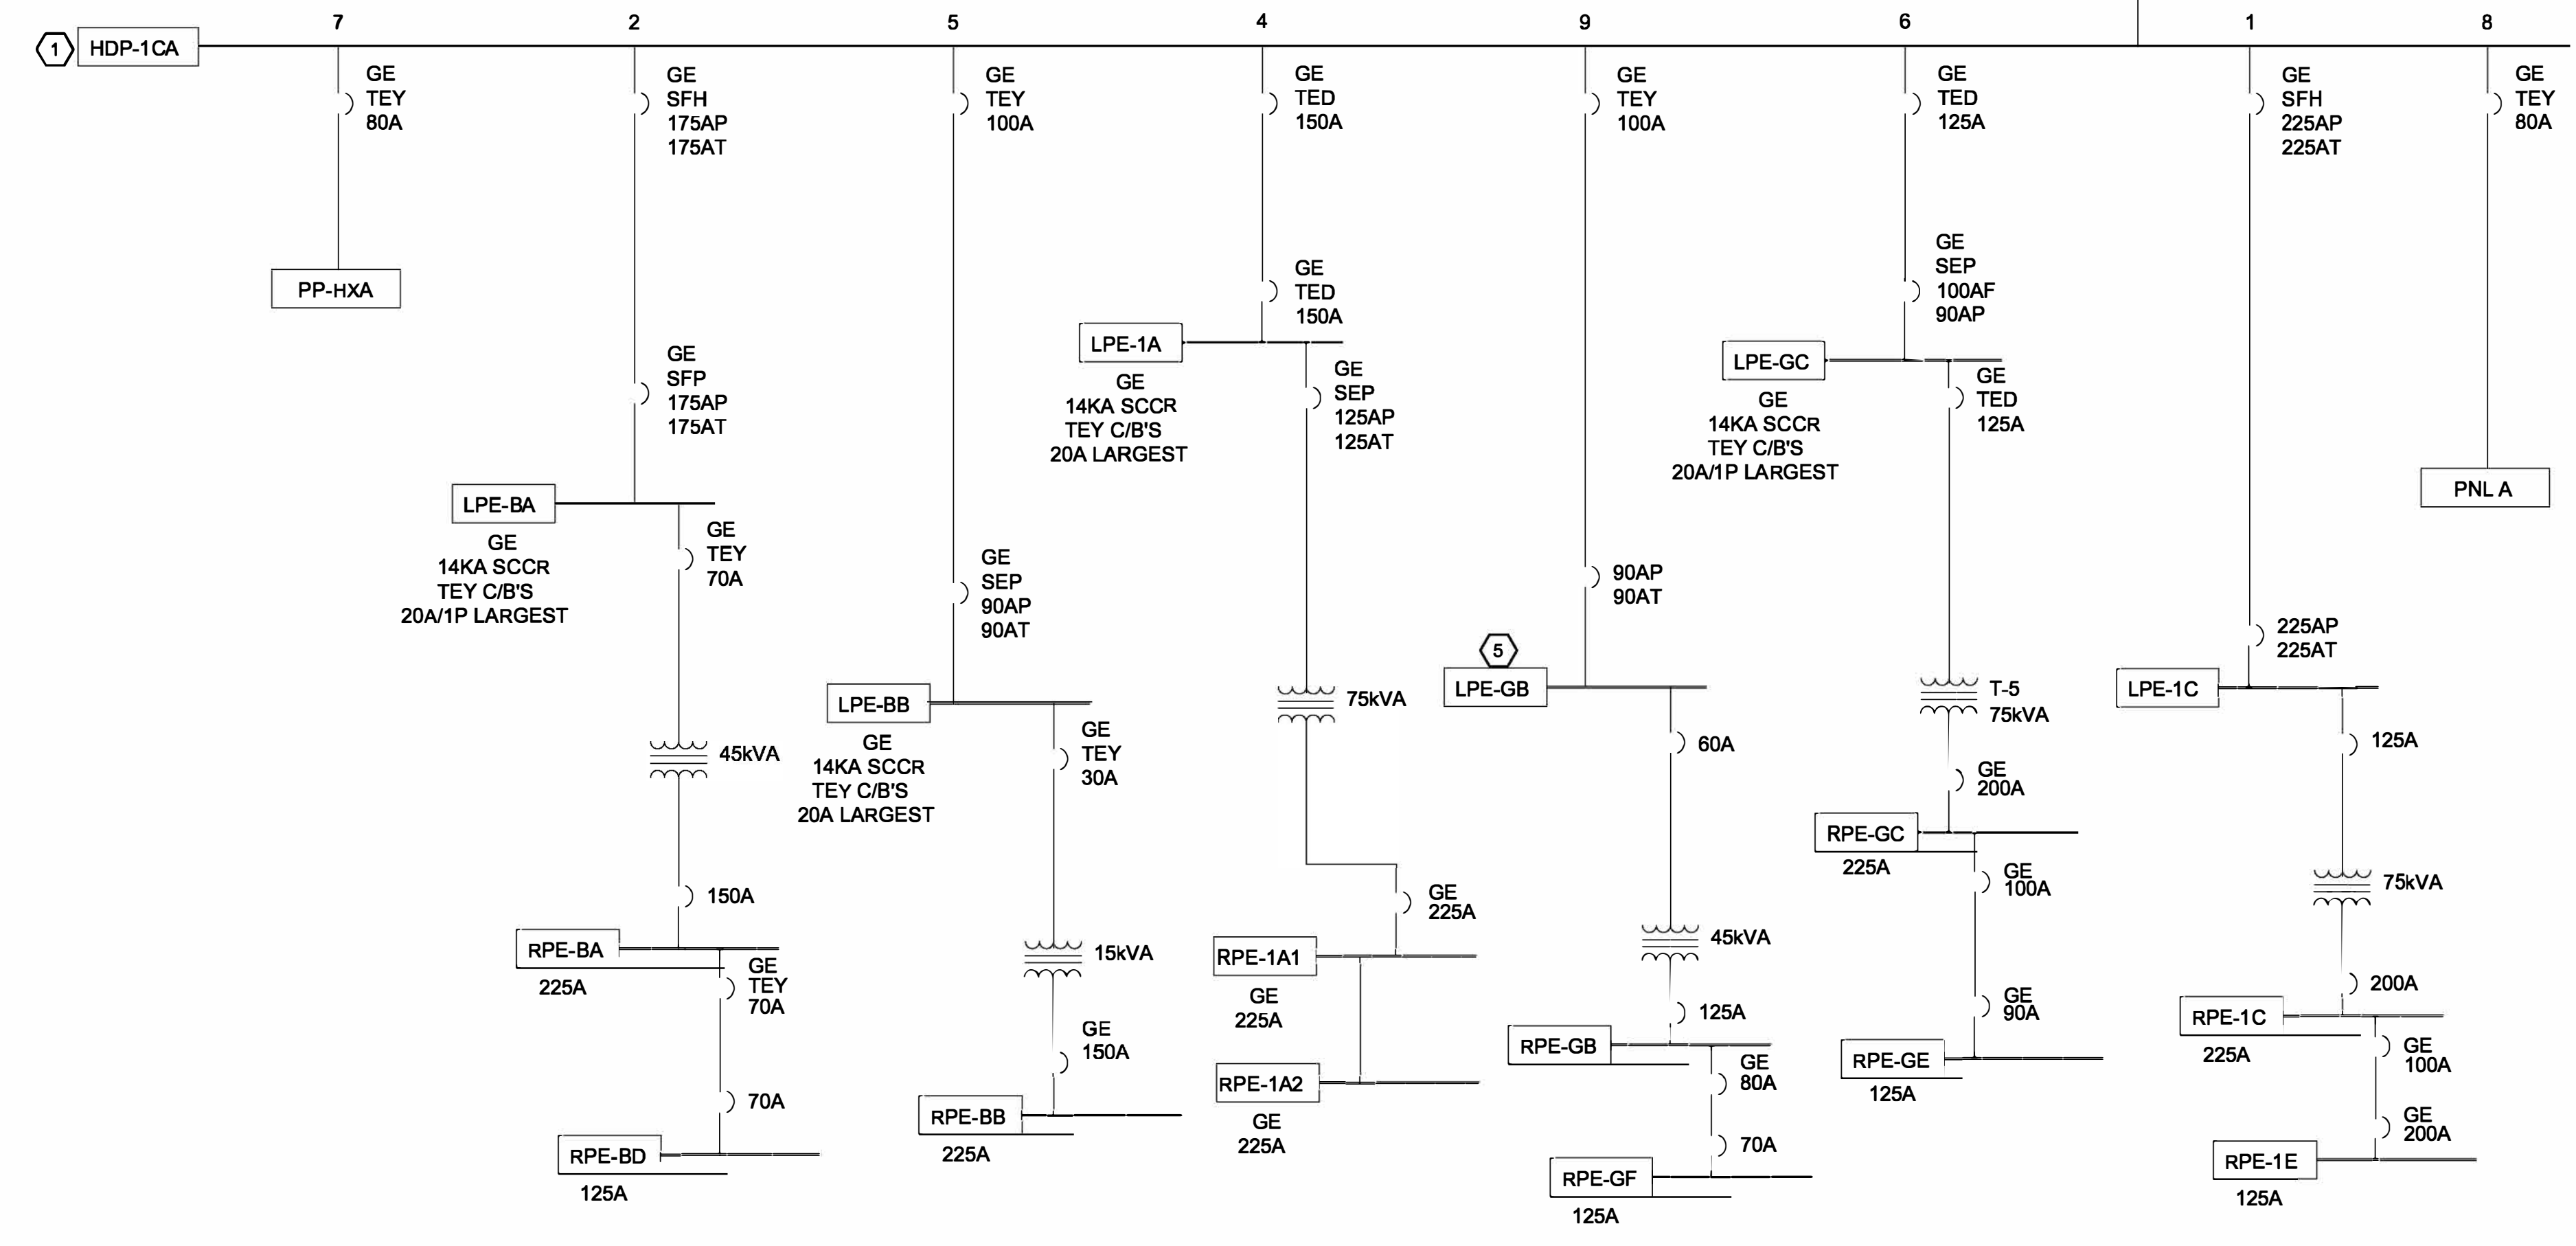



three eighths inch = one foot
one eighth inch = one foot
one quarter inch = one foot
one half inch = one foot
three quarters inch = one foot
one inch = one foot
one and one half inches = one foot
two inches = one foot
three inches = one foot
four inches = one foot
five inches = one foot
six inches = one foot
seven inches = one foot
eight inches = one foot
nine inches = one foot
ten inches = one foot
eleven inches = one foot
twelve inches = one foot
thirteen inches = one foot
fourteen inches = one foot
fifteen inches = one foot
sixteen inches = one foot
seventeen inches = one foot
eighteen inches = one foot
nineteen inches = one foot
twenty inches = one foot
twenty one inches = one foot
twenty two inches = one foot
twenty three inches = one foot
twenty four inches = one foot
twenty five inches = one foot
twenty six inches = one foot
twenty seven inches = one foot
twenty eight inches = one foot
twenty nine inches = one foot
thirty inches = one foot
thirty one inches = one foot
thirty two inches = one foot
thirty three inches = one foot
thirty four inches = one foot
thirty five inches = one foot
thirty six inches = one foot
thirty seven inches = one foot
thirty eight inches = one foot
thirty nine inches = one foot
forty inches = one foot
forty one inches = one foot
forty two inches = one foot
forty three inches = one foot
forty four inches = one foot
forty five inches = one foot
forty six inches = one foot
forty seven inches = one foot
forty eight inches = one foot
forty nine inches = one foot
fifty inches = one foot
fifty one inches = one foot
fifty two inches = one foot
fifty three inches = one foot
fifty four inches = one foot
fifty five inches = one foot
fifty six inches = one foot
fifty seven inches = one foot
fifty eight inches = one foot
fifty nine inches = one foot
sixty inches = one foot
sixty one inches = one foot
sixty two inches = one foot
sixty three inches = one foot
sixty four inches = one foot
sixty five inches = one foot
sixty six inches = one foot
sixty seven inches = one foot
sixty eight inches = one foot
sixty nine inches = one foot
seventy inches = one foot
seventy one inches = one foot
seventy two inches = one foot
seventy three inches = one foot
seventy four inches = one foot
seventy five inches = one foot
seventy six inches = one foot
seventy seven inches = one foot
seventy eight inches = one foot
seventy nine inches = one foot
eighty inches = one foot
eighty one inches = one foot
eighty two inches = one foot
eighty three inches = one foot
eighty four inches = one foot
eighty five inches = one foot
eighty six inches = one foot
eighty seven inches = one foot
eighty eight inches = one foot
eighty nine inches = one foot
ninety inches = one foot
ninety one inches = one foot
ninety two inches = one foot
ninety three inches = one foot
ninety four inches = one foot
ninety five inches = one foot
ninety six inches = one foot
ninety seven inches = one foot
ninety eight inches = one foot
ninety nine inches = one foot
one hundred inches = one foot

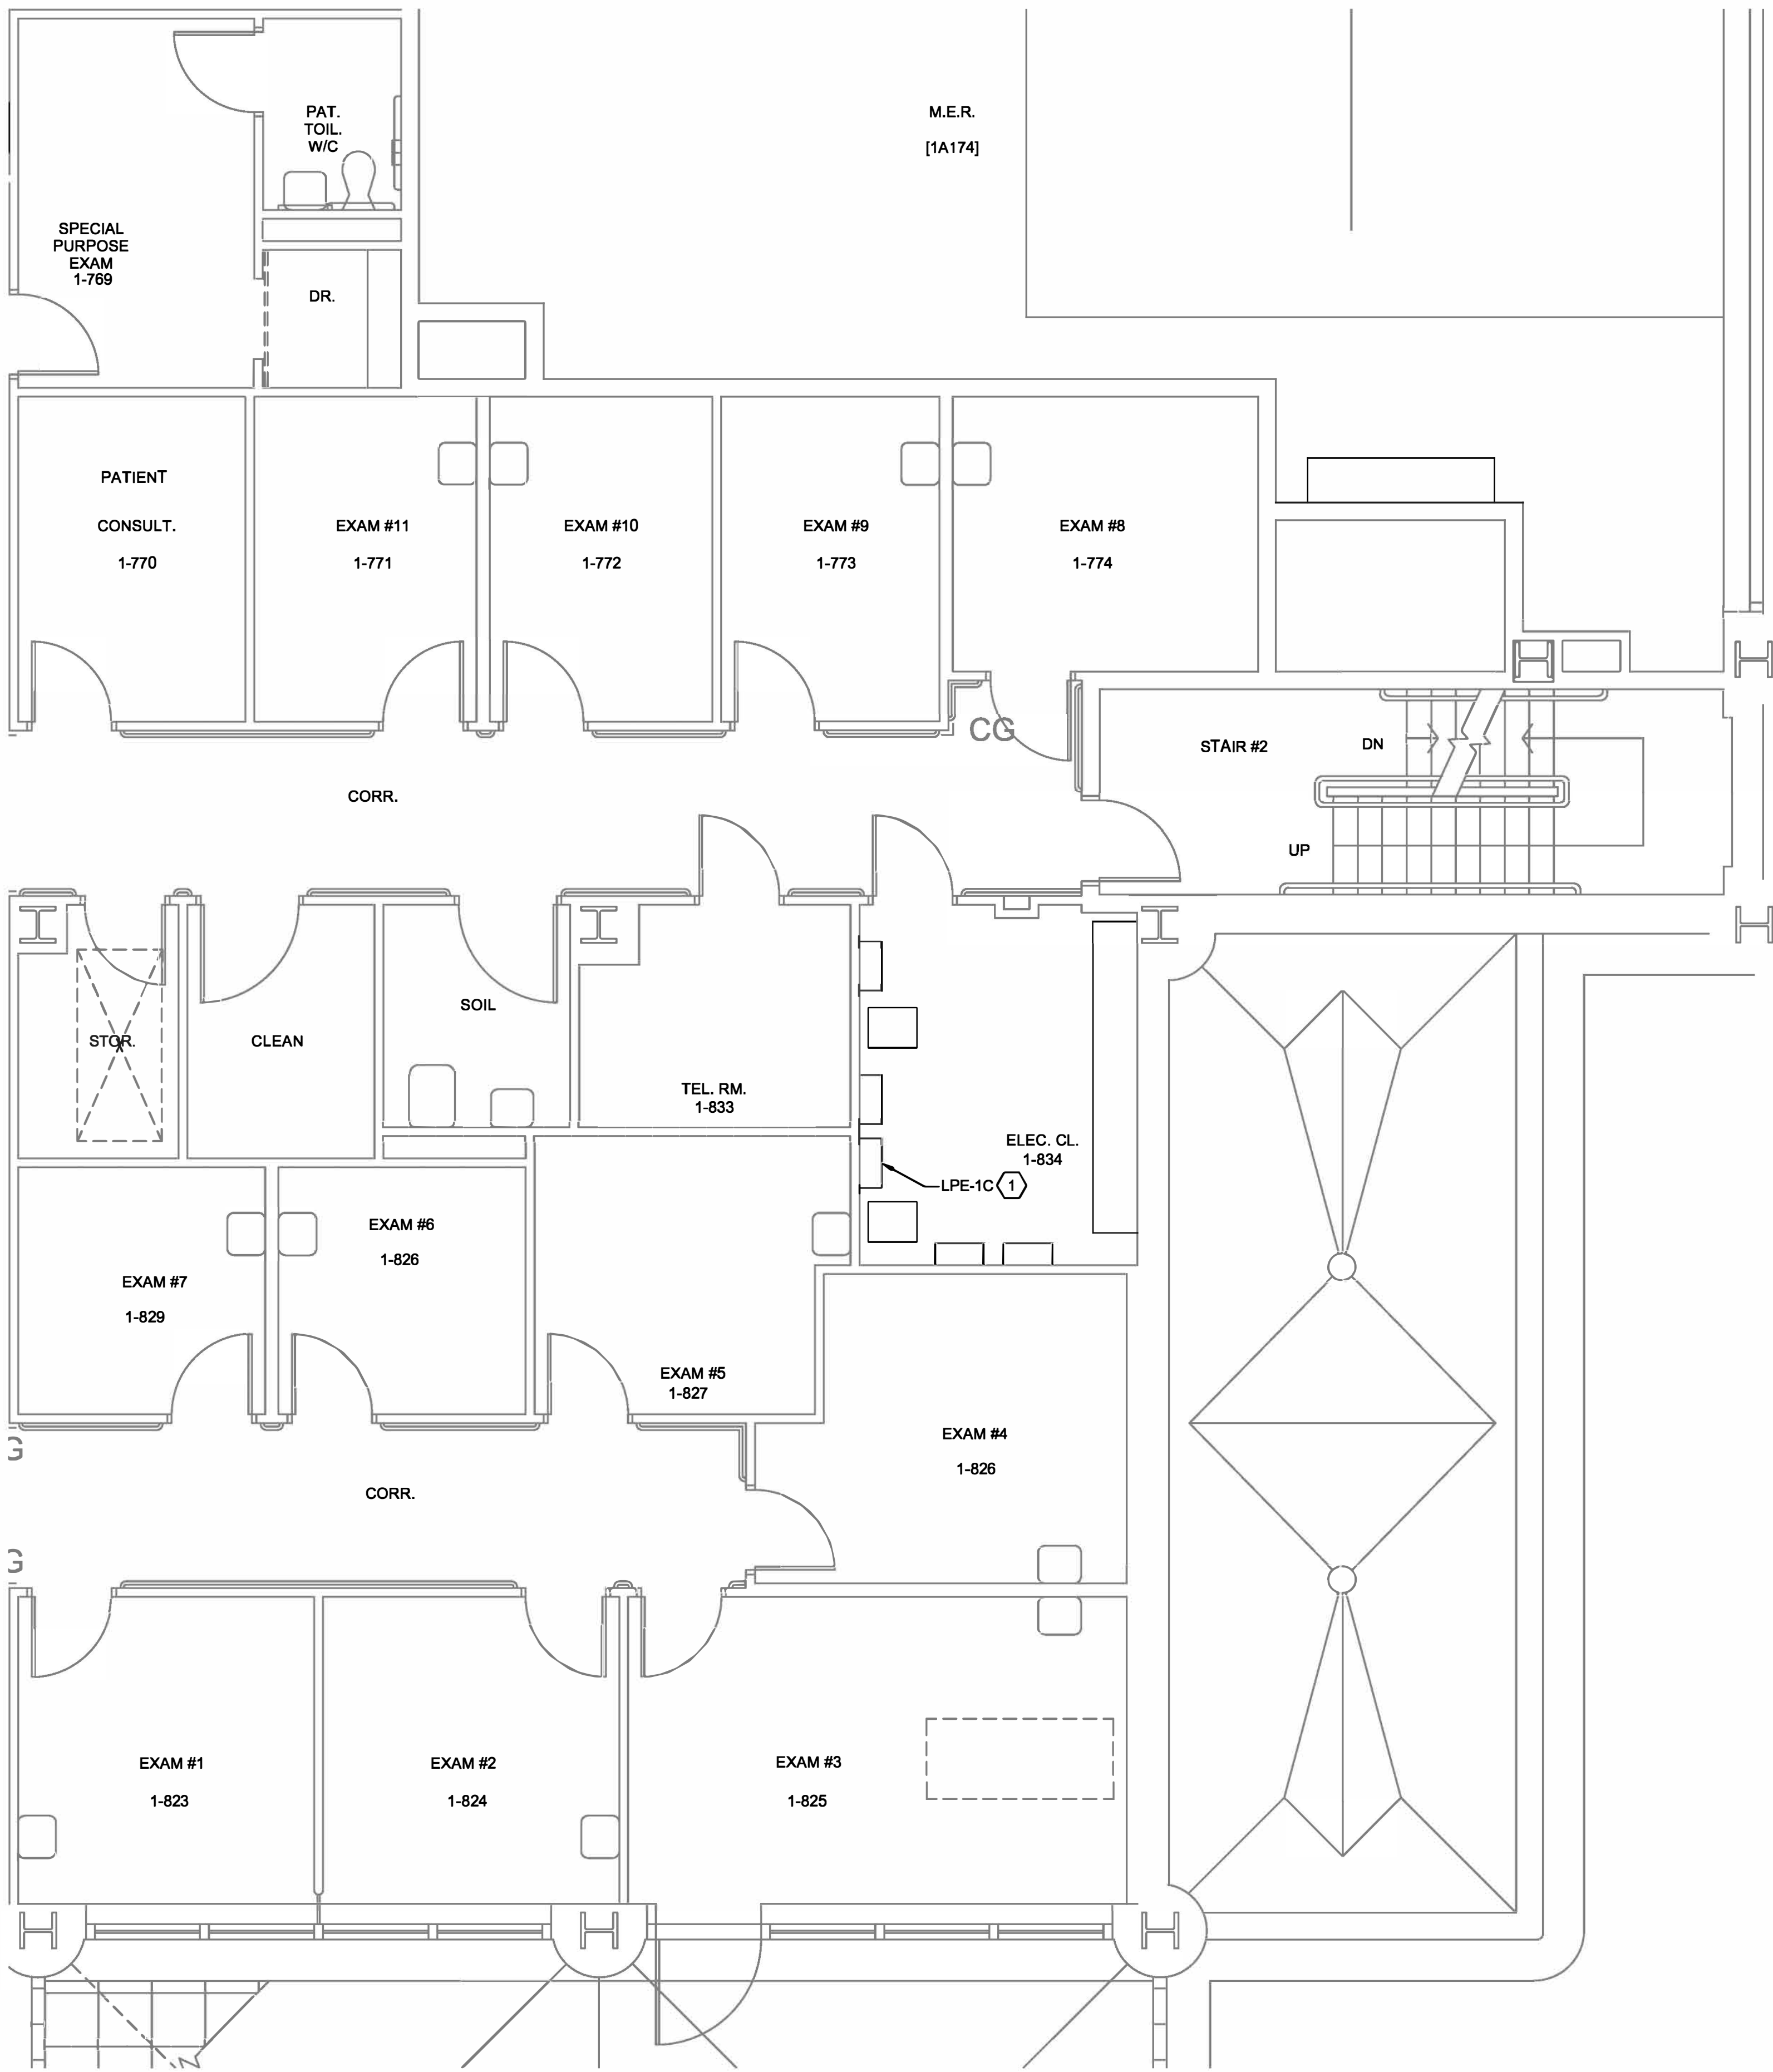

A1 PARTIAL BUILDING 15 FIRST FLOOR PLAN
1/4"=1'-0"
4' 2' 0' 2' 4'


DRAWING NOTES:
1. WORK SHOWN THIS DRAWING SHALL TAKE PLACE ON NIGHT/WEEKEND SHIFTS.

DRAWING KEYNOTES:
1. DE-ENERGIZE, DISCONNECT, REMOVE AND REPLACE SURFACE MOUNTED PANEL INDICATED. DISCONNECT FEEDER AND BRANCH CIRCUIT CONDUCTORS TO FACILITATE PANEL REPLACEMENT. PROVIDE ALL MATERIAL AND LABOR TO TERMINATE FEEDER AND BRANCH CIRCUIT CONDUCTORS TO REPLACEMENT PANEL INCLUDING ANY REQUIRED CABLE EXTENSIONS. REFER TO PANEL SCHEDULE THIS DRAWING. PANEL AND CIRCUIT BREAKERS SHALL MEET/EXCEED SHORT CIRCUIT BRACING INDICATED IN PANEL SCHEDULE.

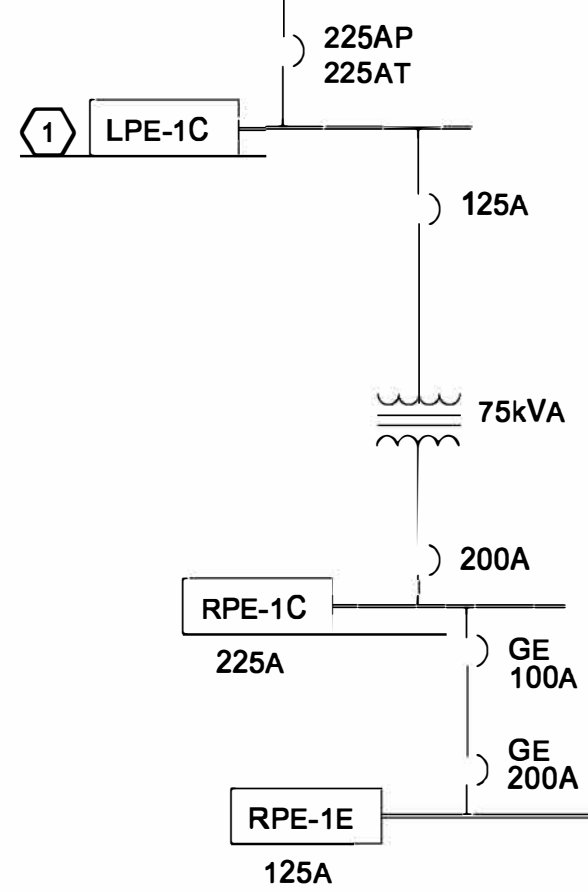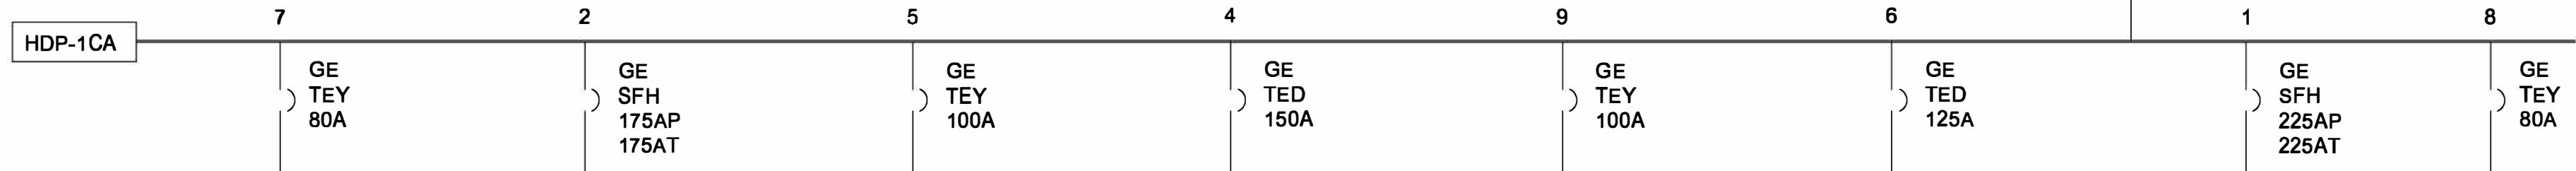

A5 PARTIAL BUILDING 15 ONE-LINE DIAGRAM
NOT TO SCALE
ONE-LINE DIAGRAM NOTES:
1. NOT ALL BRANCH/FEEDER CIRCUITS ARE NOT SHOWN ON ONE-LINE DIAGRAM.

PANEL SCHEDULE											
POWER PANEL		LPE-1C		LOCATION ELEC CLOSET 1-834		INSTALLATION		SURFACE			
RATINGS		225A		AMPS 480Y/277V		VOLTS 3 PH		4 WIRE, 60 HZ		GRD. BAR YES	
MAIN LUGS				CB. INTERRUPTING RATING		30kAIC		RMS. SYMM. AMPS			
MAIN CIRCUIT BREAKER		225A		AMPS		CONNECTED LOAD		KW, PANEL SIZE		30 SPACES	
DESCRIPTION	LOAD	CB.	CIR	DESCRIPTION	LOAD	CB.	CIR	DESCRIPTION	LOAD	CB.	CIR
1ST FL NORTH STH.	20	1	1	2	20	1	1	SPARE (ON)	20	1	1
1C131, 132, 125	20	3	1	4	20	1	1	SPARE (ON)	20	1	1
1A164, 1C134, 1C133	20	5	1	6	20	1	1	SPARE (ON)	20	1	1
SPARE (ON)	20	7	1	8	20	1	1	SPARE (ON)	20	1	1
SPARE (ON)	20	9	1	10	20	1	1	SPARE (ON)	20	1	1
SPARE (ON)	20	11	1	12	20	1	1	SPARE (ON)	20	1	1
SPARE (ON)	20	13	1	14	20	1	1	SPARE (ON)	20	1	1
RPE-1C VIA XFMR	125	15	1	16	20	1	1	SPARE (ON)	20	1	1
		17	1	18	20	1	1	SPACE			
		19	1	20	20	1	1	SPACE			
		21	1	22	20	1	1	SPACE			
		23	1	24	20	1	1	SPACE			
		25	1	26	20	1	1	SPACE			
		27	1	28	20	1	1	SPACE			
		29	1	30	20	1	1	SPACE			

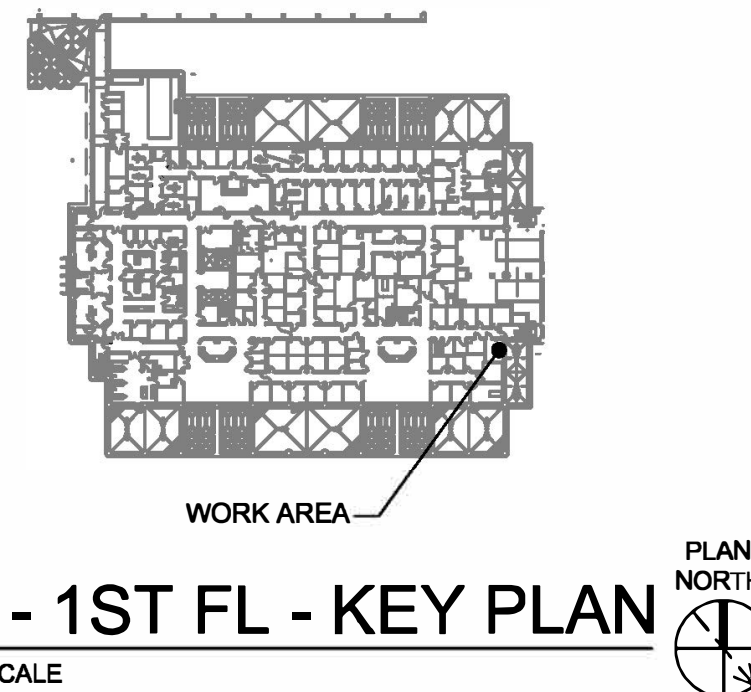


B15 - 1ST FL - KEY PLAN
NOT TO SCALE

CONSULTANTS: RAMBOLL RAMBOLL AMERICAS ENGINEERING SOLUTIONS, INC. 18 LINK DRIVE BINGHAMTON, NY 13902		ARCHITECT/ENGINEERS: D2X Associates 259 St. Ives Dr. Talent, OR 97540		APPROVED BY: VJC DATE: 08/24/22		Drawing Title TASK ORDER 5 PANEL LPE-1C AREA PLAN ONE-LINE DIAGRAM AND SCHEDULE Approved: Project Director		Project Title UPGRADE LIFE SAFETY CRITICAL BRANCH ELECTRICAL DISTRIBUTION NY HARBOR HEALTHCARE CENTER VA BROOKLYN CAMPUS Location 800 POLY PLACE, BROOKLYN NY 11209 Issue Date 08/24/22 Checked BKD Drawn KMB		Project Number 630A4-16-430 Building Number 15 Drawing Number 18-01-BK EP-163 Dwg. 68 of 91		Office of Construction and Facilities Management Department of Veterans Affairs	
---	--	--	--	--	--	--	--	--	--	--	--	---	--


three inches = one foot
one and one half inches = one foot
one inch = one foot
three quarters inch = one foot
one half inch = one foot
three eighths inch = one foot
one quarter inch = one foot
one eighth inch = one foot

A
B
C
D
E
F

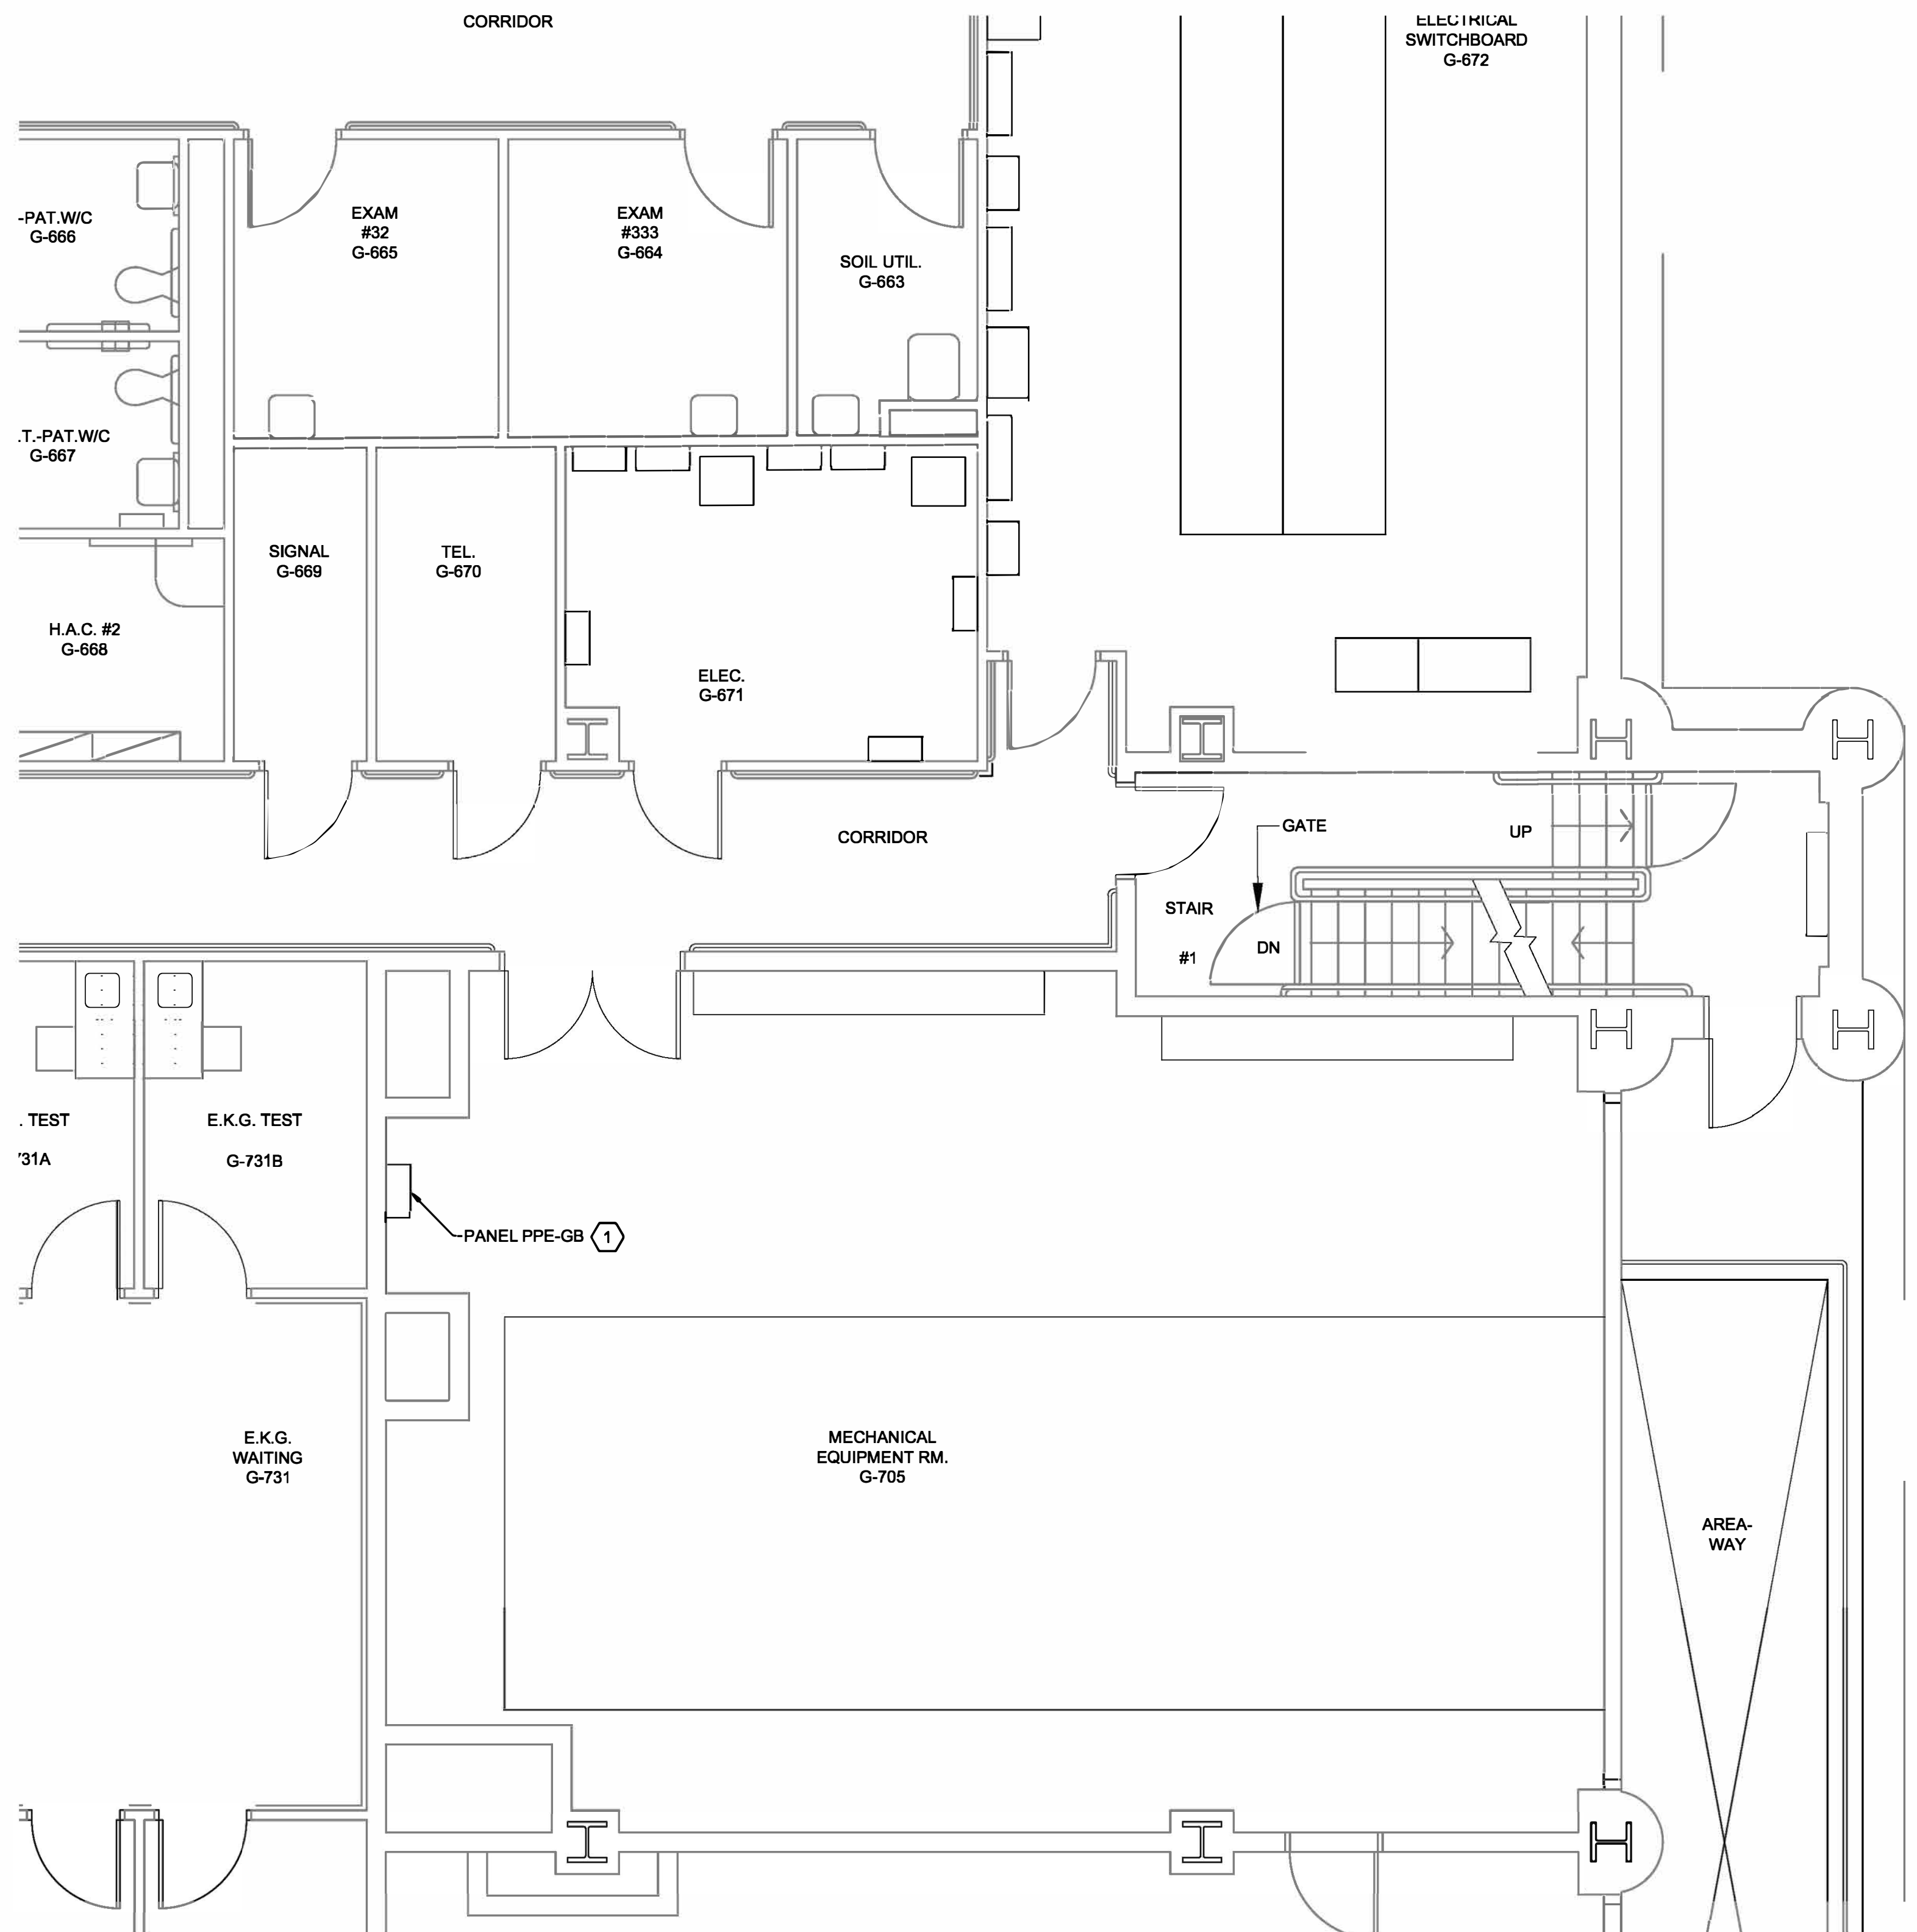

A1 PARTIAL BUILDING 15 GROUND FLOOR PLAN
1/4"=1'-0" 4' 2' 0' 2' 4'


- DRAWING NOTES:**
- WORK SHOWN THIS DRAWING SHALL BE COORDINATED WITH THE VA TO TAKE PLACE DURING SHOULDER MONTHS FOR THE HEATING/COOLING SEASONS BEGINNING ON A WEEKEND SHIFT.
 - DE-ENERGIZE, DISCONNECT, REMOVE AND REPLACE SURFACE MOUNTED PANEL INDICATED. DISCONNECT FEEDER AND BRANCH CIRCUIT CONDUCTORS TO FACILITATE PANEL REPLACEMENT. PROVIDE ALL MATERIAL AND LABOR TO TERMINATE FEEDER AND BRANCH CIRCUIT CONDUCTORS TO REPLACEMENT PANEL INCLUDING ANY REQUIRED CABLE EXTENSIONS. REFER TO PANEL SCHEDULE THIS DRAWING. PANEL AND CIRCUIT BREAKERS SHALL MEET/EXCEED SHORT CIRCUIT CURRENT RATING INDICATED IN PANEL SCHEDULE.

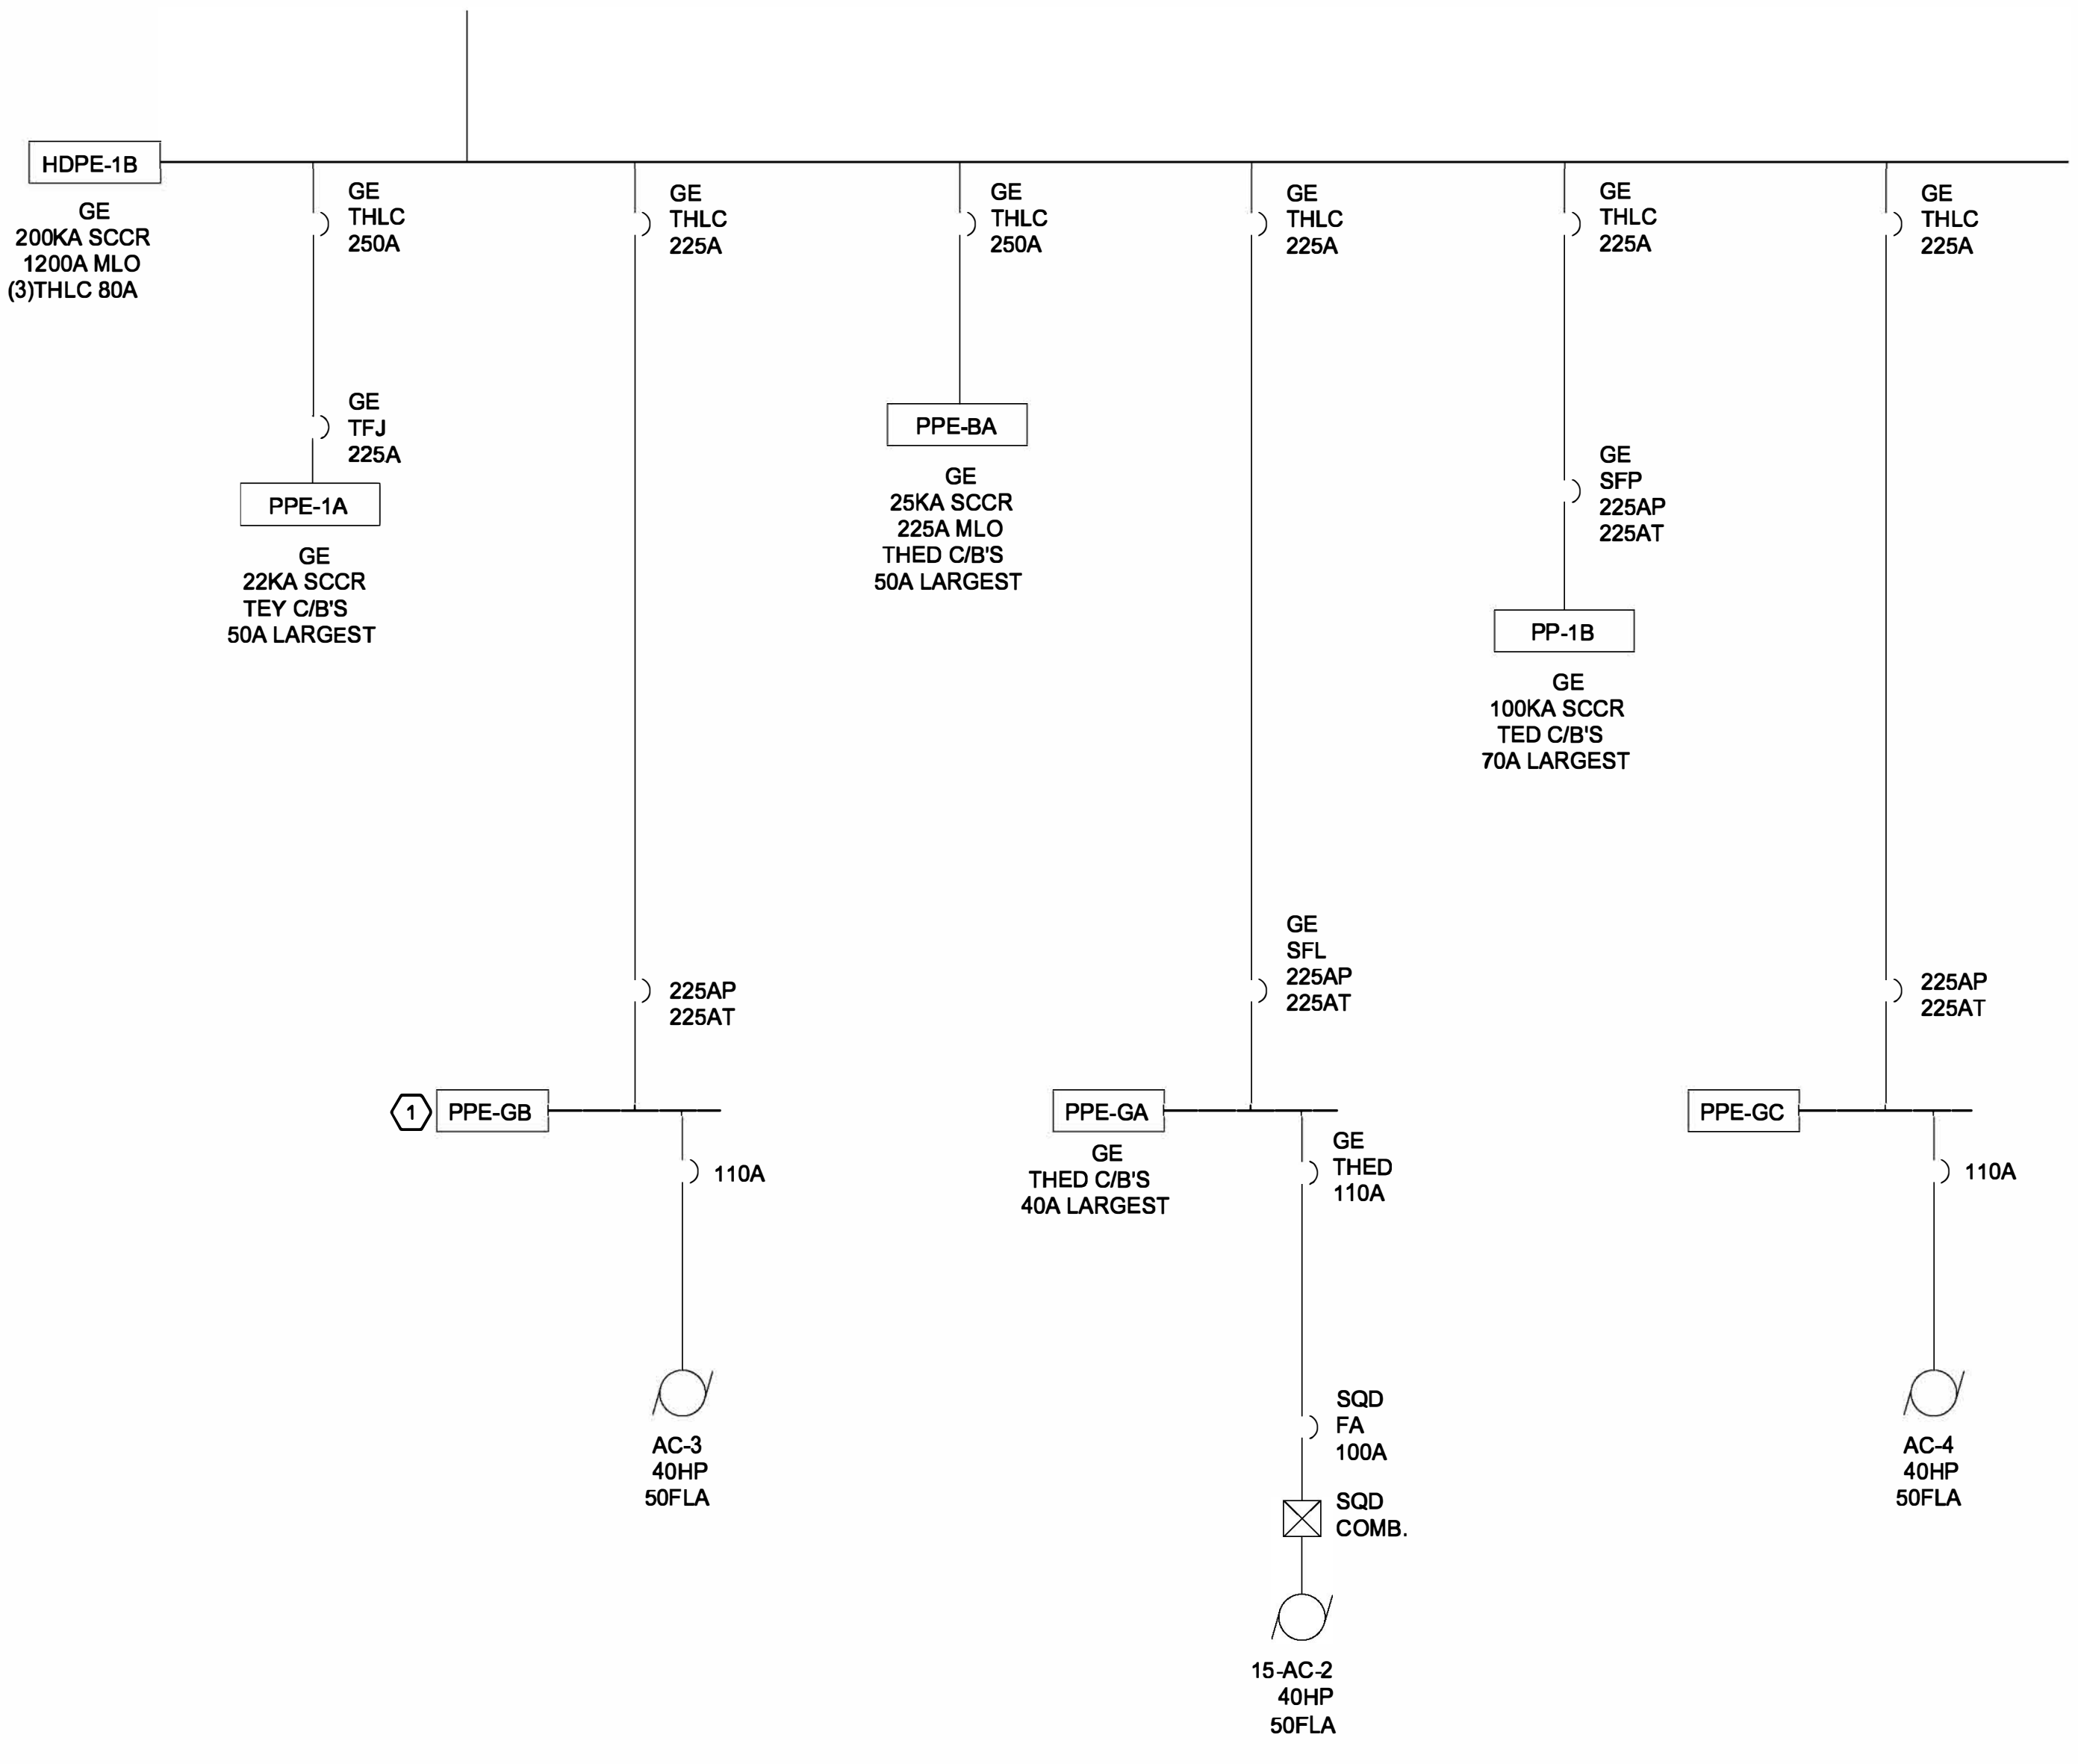

A5 PARTIAL BUILDING 15 ONE-LINE DIAGRAM
NOT TO SCALE


- ONE-LINE DIAGRAM NOTES:**
- NOT ALL BRANCH/FEEDER CIRCUITS ARE NOT SHOWN ON ONE-LINE DIAGRAM.

PANEL SCHEDULE									
POWER PANEL	PPE-GB	LOCATION	MECH RM G-705	INSTALLATION	SURFACE				
RATINGS	225A	AMPS	480Y/277V	VOLTS	3 PH	4	WIRE	60	HZ
MAIN LUGS	-	CB INTERRUPTING RATING	65KAIC	RMS	SYMM	AMPS			
MAIN CIRCUIT BREAKER	225A	AMPS	CONNECTED LOAD	-	KW	PANEL SIZE	42	SPACES	
DESCRIPTION	LOAD WKKWHP	CB AMPS	CIR	A	B	C	CIR	CB AMPS	LOAD WKKWHP
AC-3		110	1	2	3	4	5	6	AC-3 (40HP)
EF-26		20	9	10	11	12	13	14	AC3-2
15-PAC-3		45	15	16	17	18	19	20	15-P-AC3-2
AC3 GLYCOL		20	21	22	23	24	25	26	SPARE (ON)
SPARE (ON)		20	27	28	29	30	31	32	SPARE (ON)
SPARE (ON)		20	33	34	35	36	37	38	SPACE
SPACE			39	40	41	42			SPACE

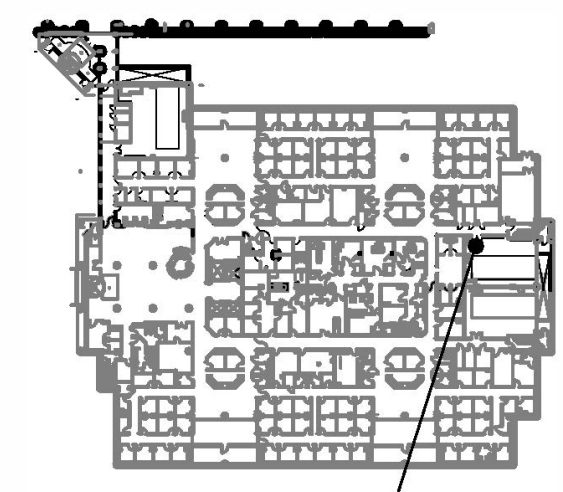


B15 - GROUND FL - KEY PLAN
NOT TO SCALE

CONSULTANTS: RAMBOLL AMERICAS ENGINEERING SOLUTIONS, INC. 18 LINK DRIVE BINGHAMTON, NY 13902		STAMP 2022-08-17	ARCHITECT/ENGINEERS: 259 St. Ives Dr. Talent, OR 97540	APPROVED BY: VJC DATE: 08/24/22	Drawing Title TASK ORDER 5 PANEL PPE-GB AREA PLAN ONE-LINE DIAGRAM AND SCHEDULE Approved: Project Director	Project Title UPGRADE LIFE SAFETY/CRITICAL BRANCH ELECTRICAL DISTRIBUTION NY HARBOR HEALTHCARE CENTER VA BROOKLYN CAMPUS Location 800 POLY PLACE, BROOKLYN NY 11209 Issue Date 08/24/22 Checked BKD Drawn KMB	Project Number 630A4-16-430 Building Number 15 Drawing Number 18-01-BK EP-165 Dwg. 70 of 91	Office of Construction and Facilities Management
--	--	--------------------------------	---	--	--	--	---	---

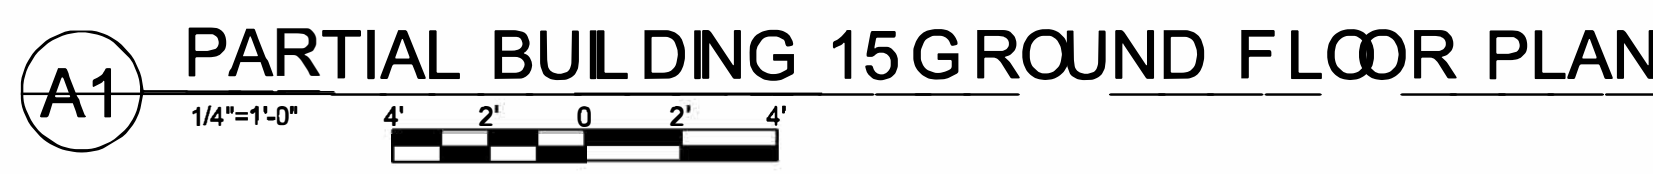

PLAN
NORTH

 Department of
Veterans Affairs

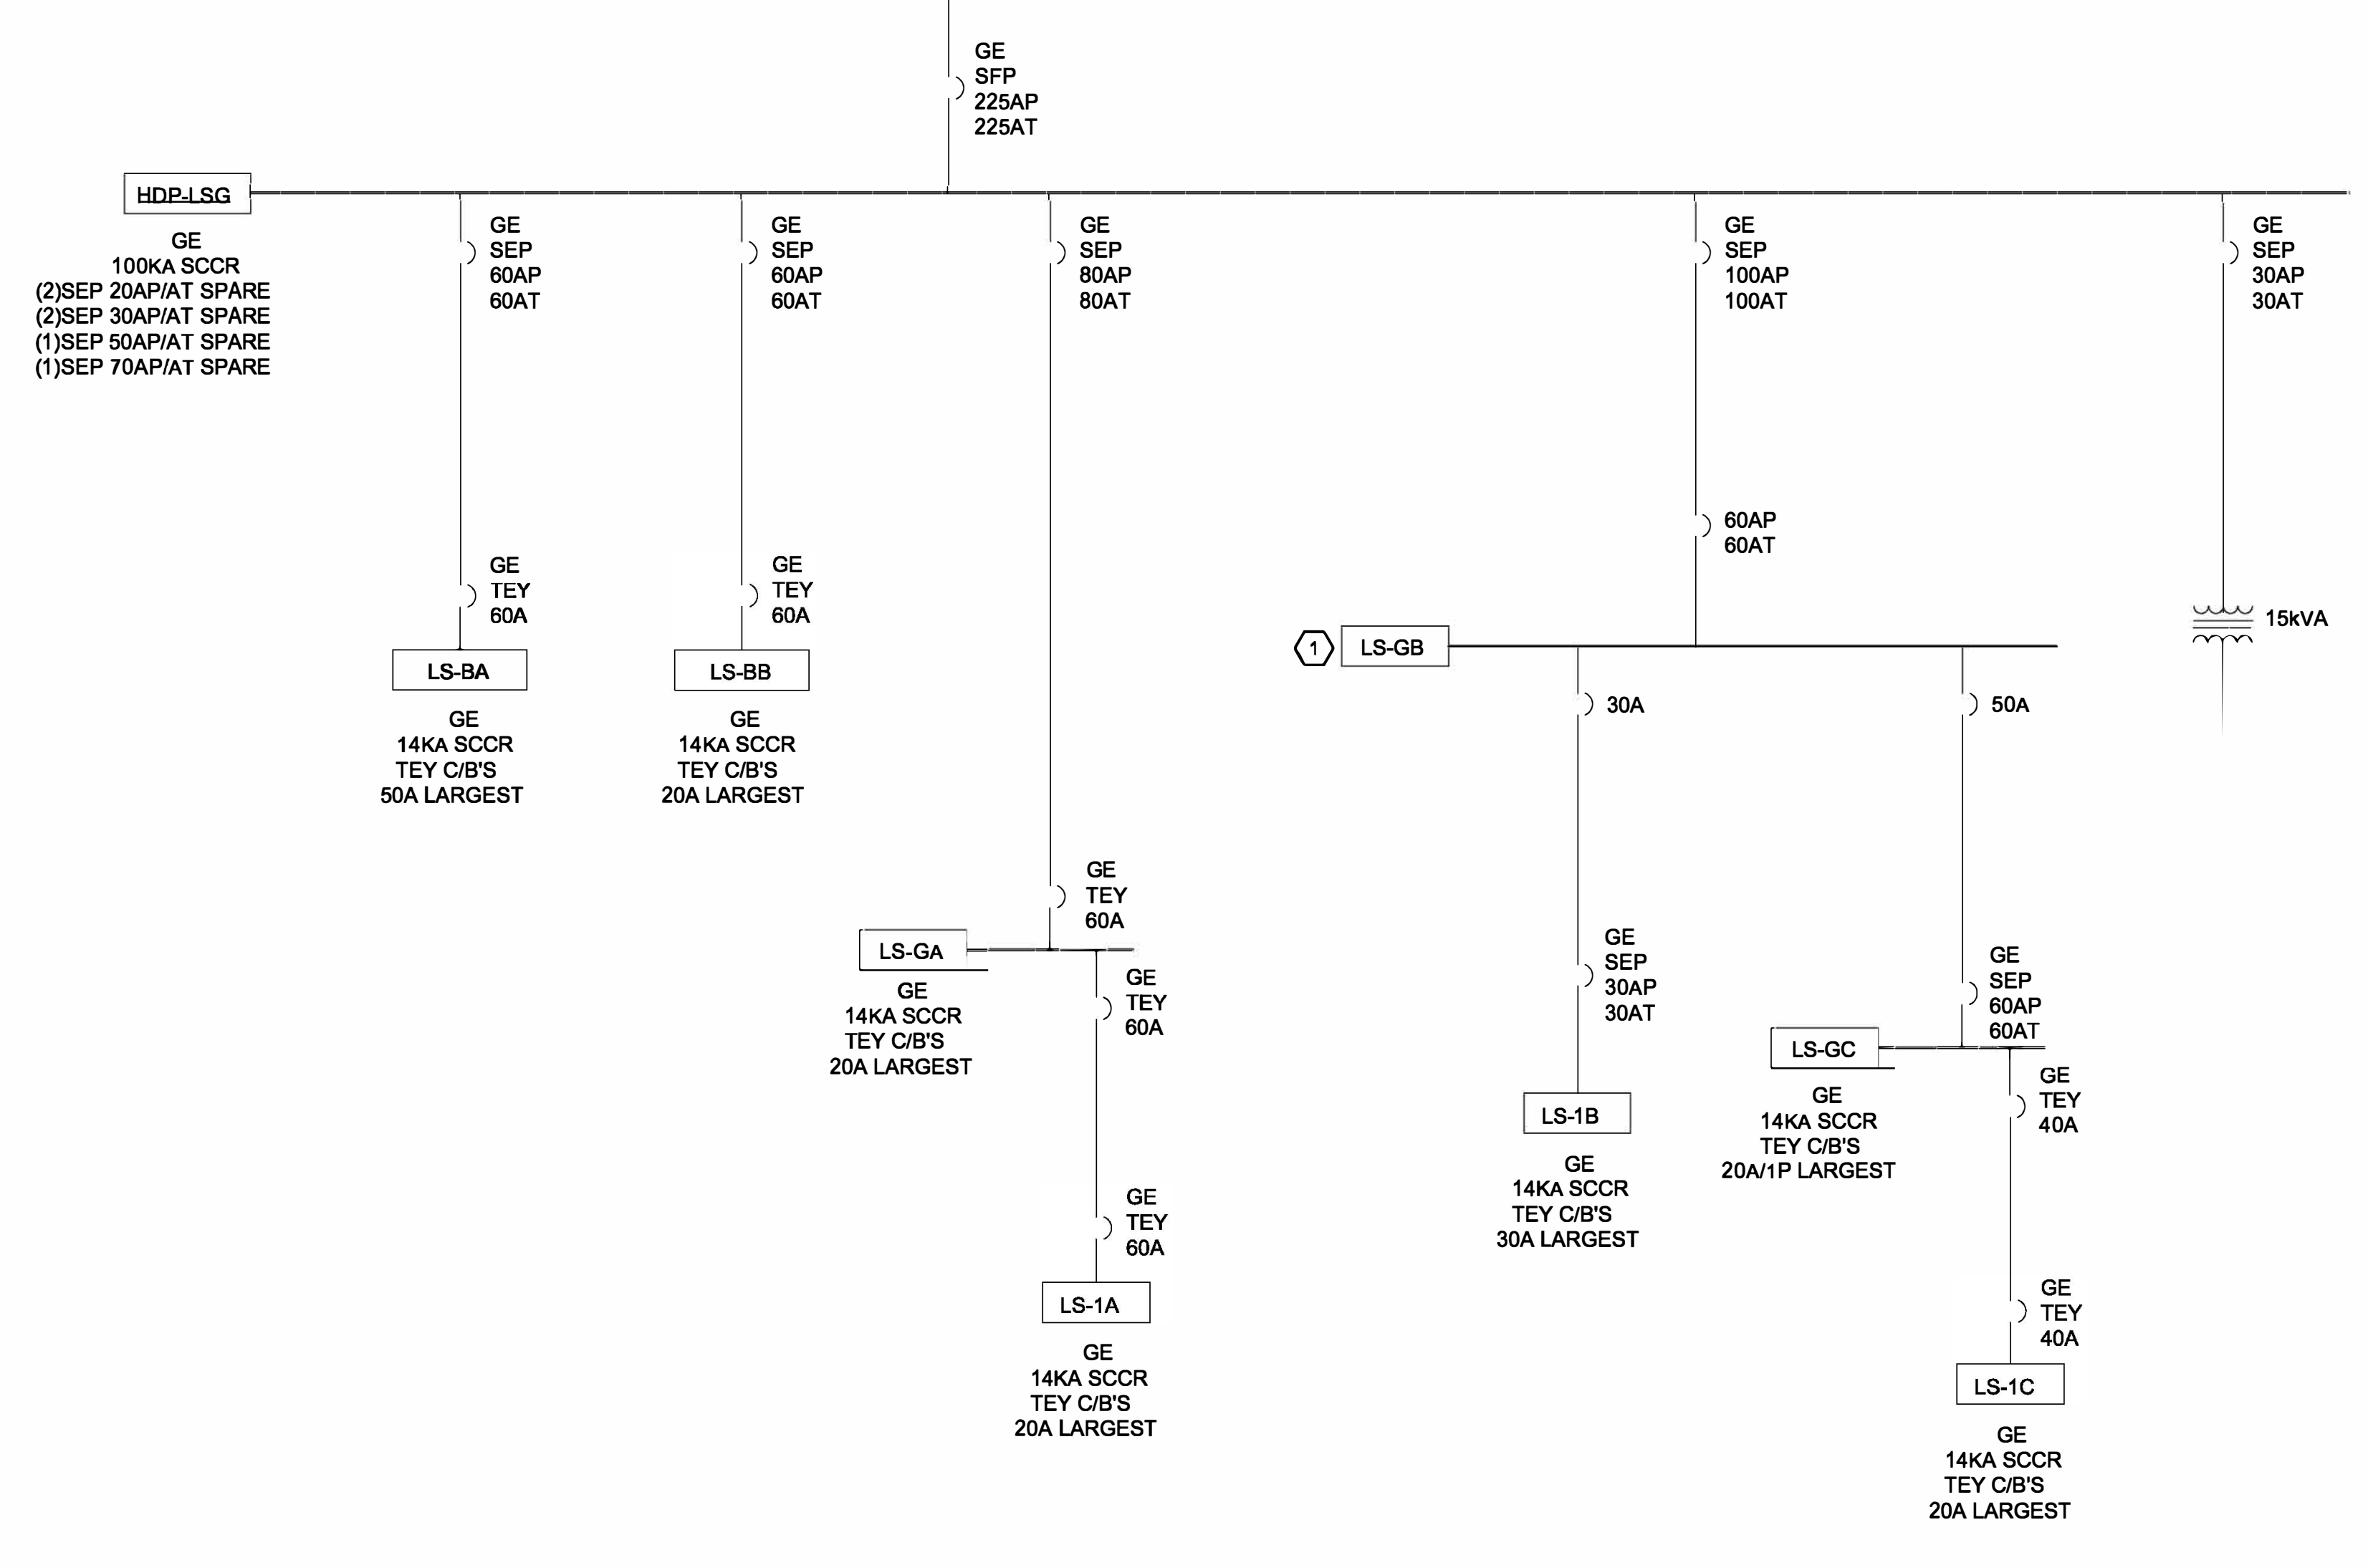


A5 PARTIAL BUILDING 15 ONE-LINE DIAGRAM
NOT TO SCALE

ONE-LINE DIAGRAM NOTES:

1. NOT ALL BRANCH/FEEDER CIRCUITS ARE NOT SHOWN ON ONE-LINE DIAGRAM

PLAN
NORTH



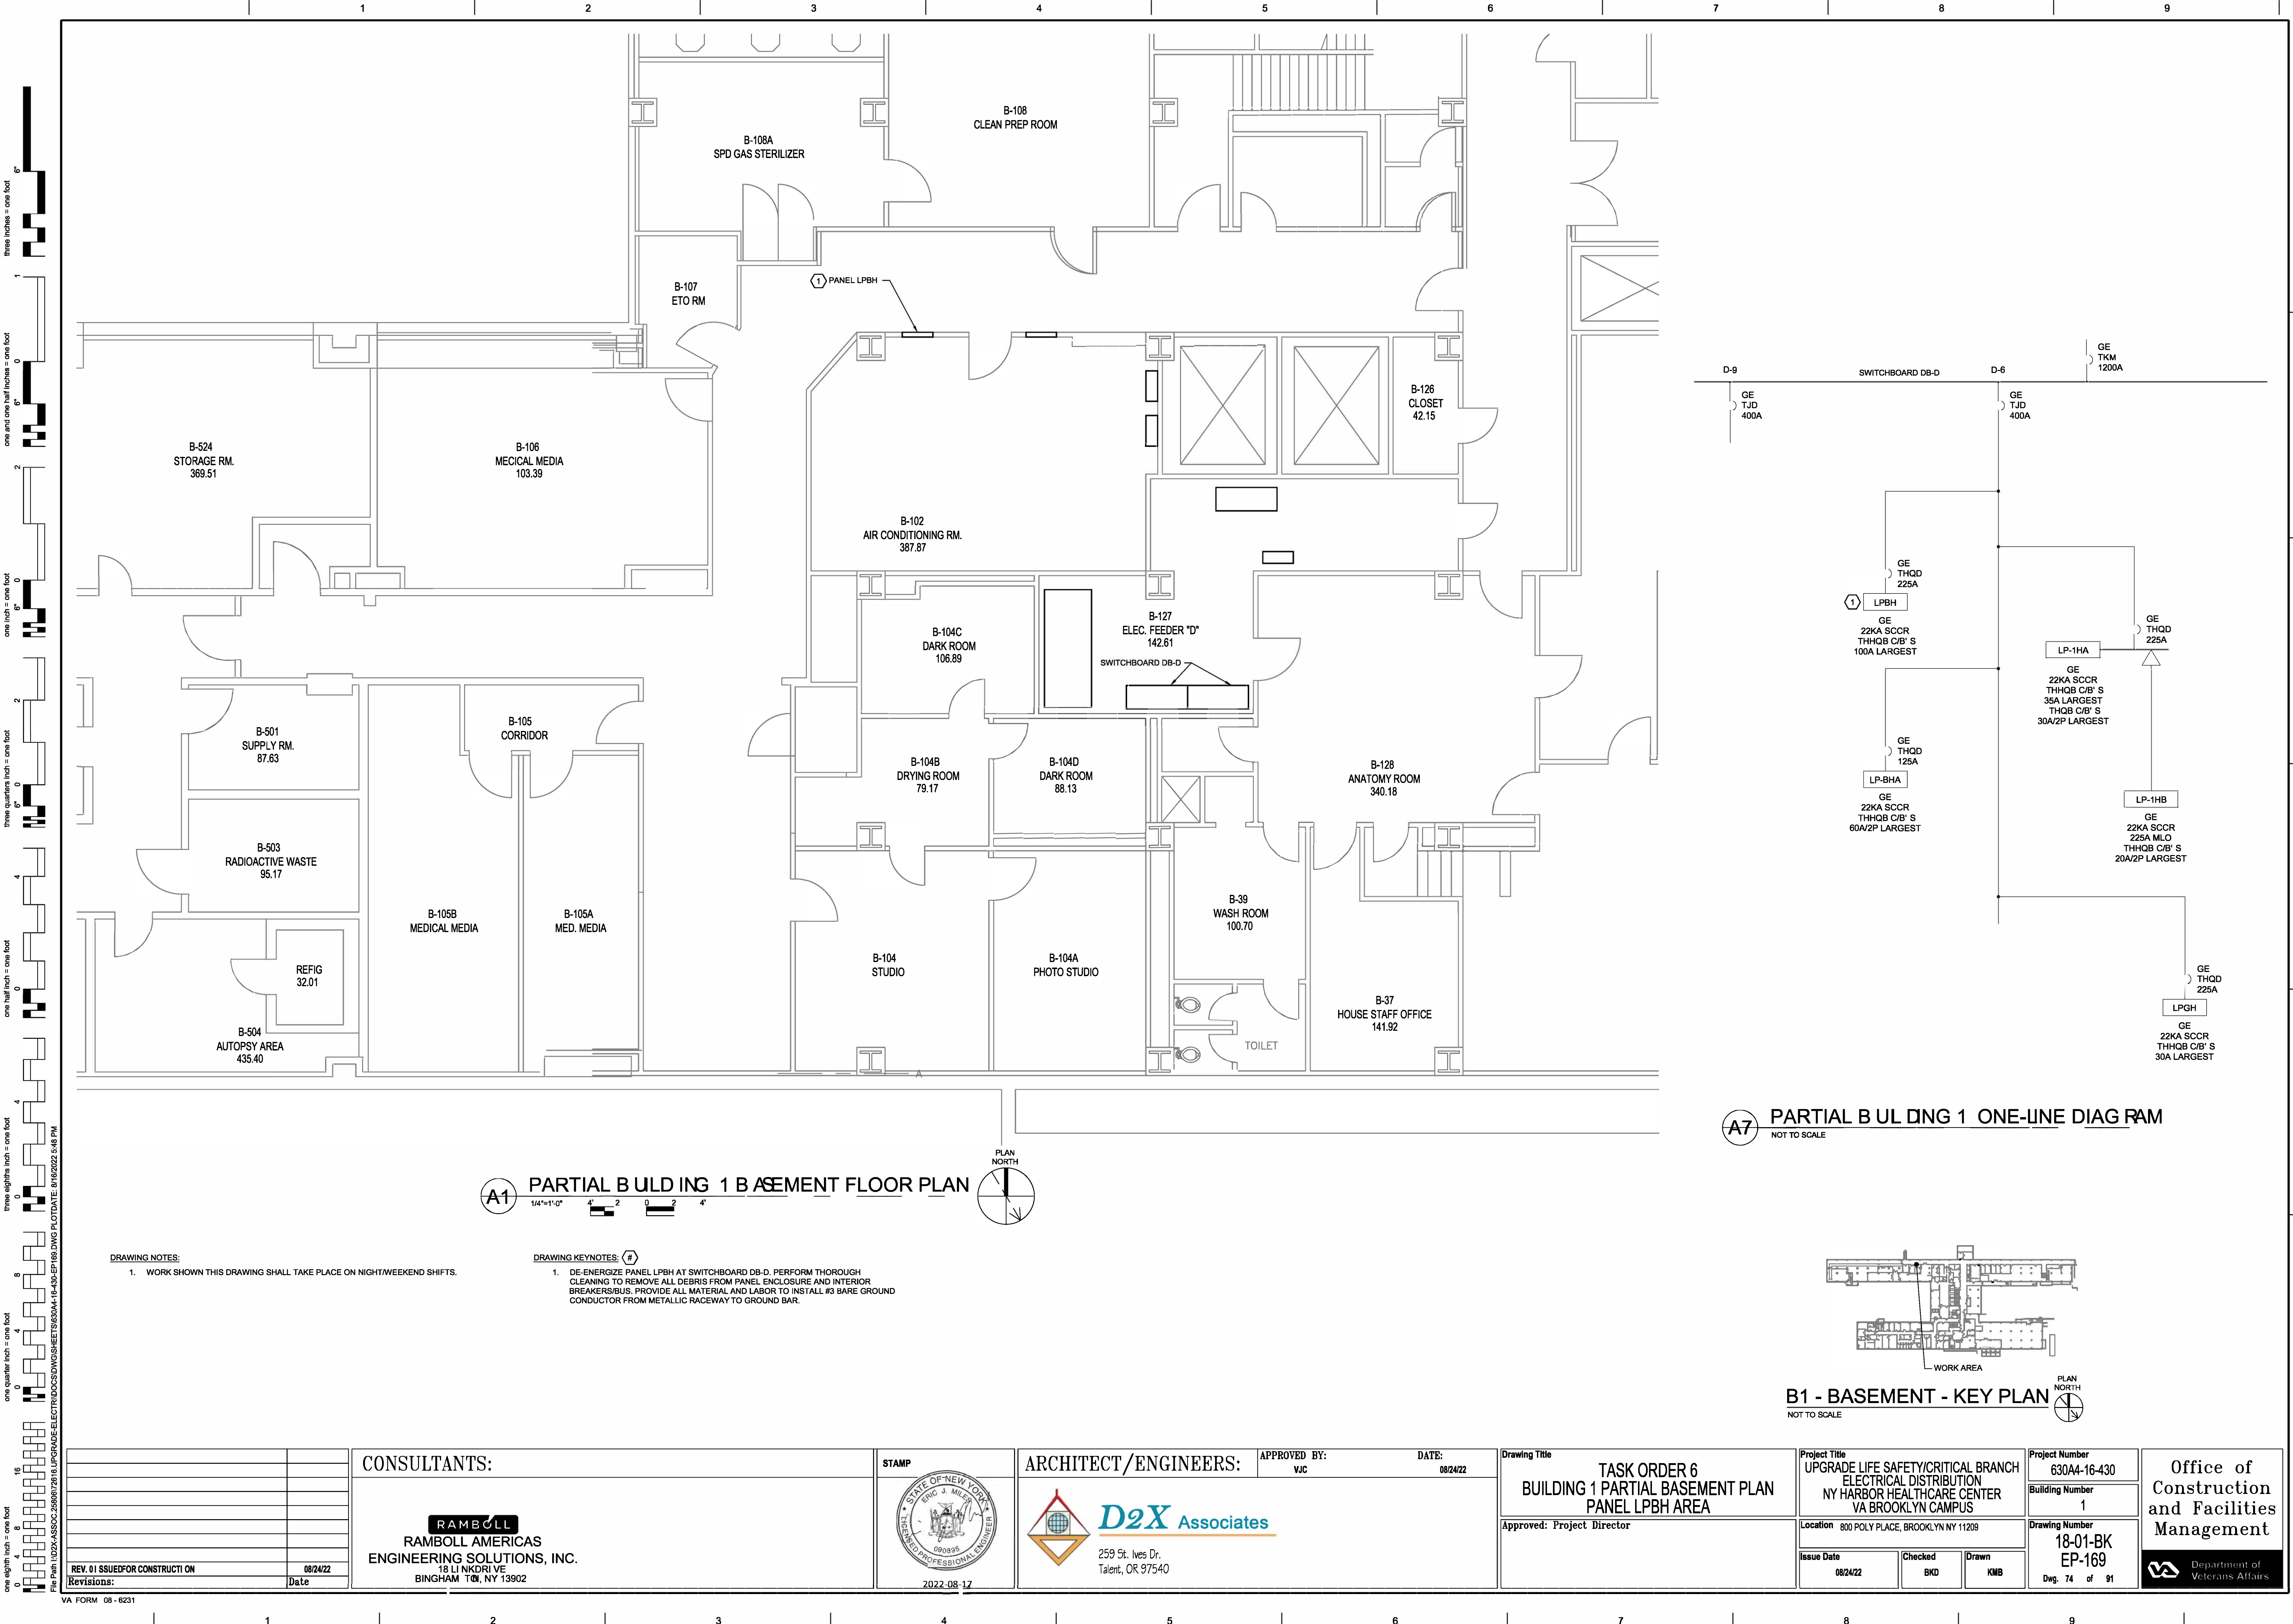


three eighths inch = one foot
one and one half inches = one foot
one inch = one foot
three quarters inch = one foot
one half inch = one foot
three eighths inch = one foot
one quarter inch = one foot
one eighth inch = one foot

A
B
C
D
E
F

A1 PARTIAL BUILDING 1 BASEMENT FLOOR PLAN
1/4"=1'-0" 4' 2' 0' 2' 4'

A7 PARTIAL BUILDING 1 ONE-LINE DIAGRAM
NOT TO SCALE


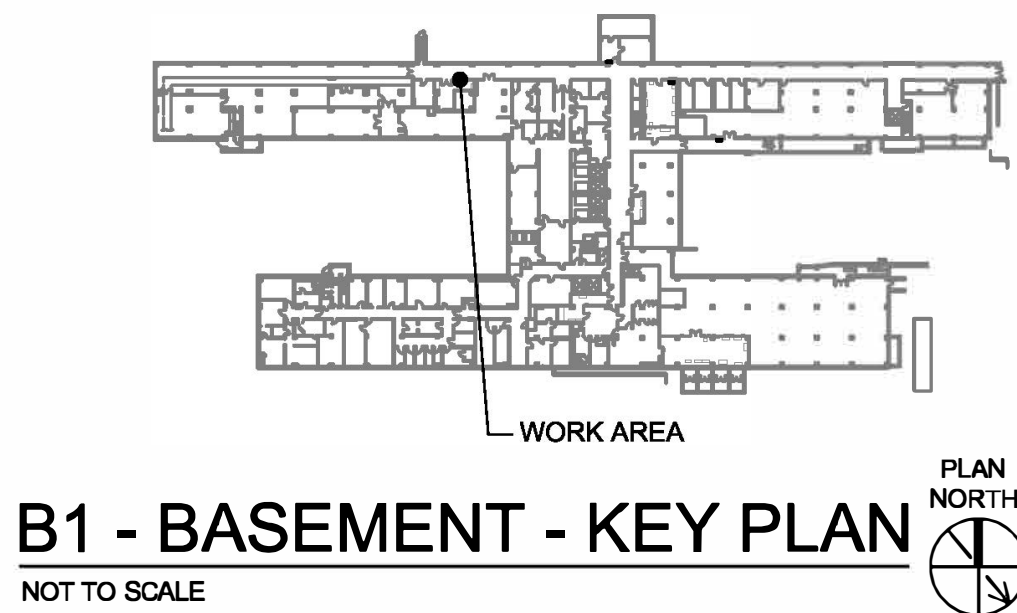


B1 - BASEMENT - KEY PLAN
NOT TO SCALE


DRAWING NOTES:
1. WORK SHOWN THIS DRAWING SHALL TAKE PLACE ON NIGHT/WEEKEND SHIFTS.

DRAWING KEYNOTES: (#)
1. DE-ENERGIZE PANEL LPBH AT SWITCHBOARD DB-D. PERFORM THOROUGH CLEANING TO REMOVE ALL DEBRIS FROM PANEL ENCLOSURE AND INTERIOR BREAKERS/BUS. PROVIDE ALL MATERIAL AND LABOR TO INSTALL #3 BARE GROUND CONDUCTOR FROM METALLIC RACEWAY TO GROUND BAR.

		CONSULTANTS:		STAMP		ARCHITECT/ENGINEERS:		APPROVED BY: VJC		DATE: 08/24/22		Drawing Title TASK ORDER 6 BUILDING 1 PARTIAL BASEMENT PLAN PANEL LPBH AREA		Project Title UPGRADE LIFE SAFETY/CRITICAL BRANCH ELECTRICAL DISTRIBUTION NY HARBOR HEALTHCARE CENTER VA BROOKLYN CAMPUS		Project Number 630A4-16-430		Office of Construction and Facilities Management			
		RAMBOLL RAMBOLL AMERICAS ENGINEERING SOLUTIONS, INC. 18 LI NKDRI VE BINGHAM TON, NY 13902		 259 St. Ives Dr. Talent, OR 97540		 D2X Associates		Approved: Project Director		08/24/22		Approved: Project Director		Location 800 POLY PLACE, BROOKLYN NY 11209		18-01-BK EP-169 Dwg. 74 of 91				 Department of Veterans Affairs	
REV. 01 ISSUED FOR CONSTRUCTION																					
Revisions:		Date																			

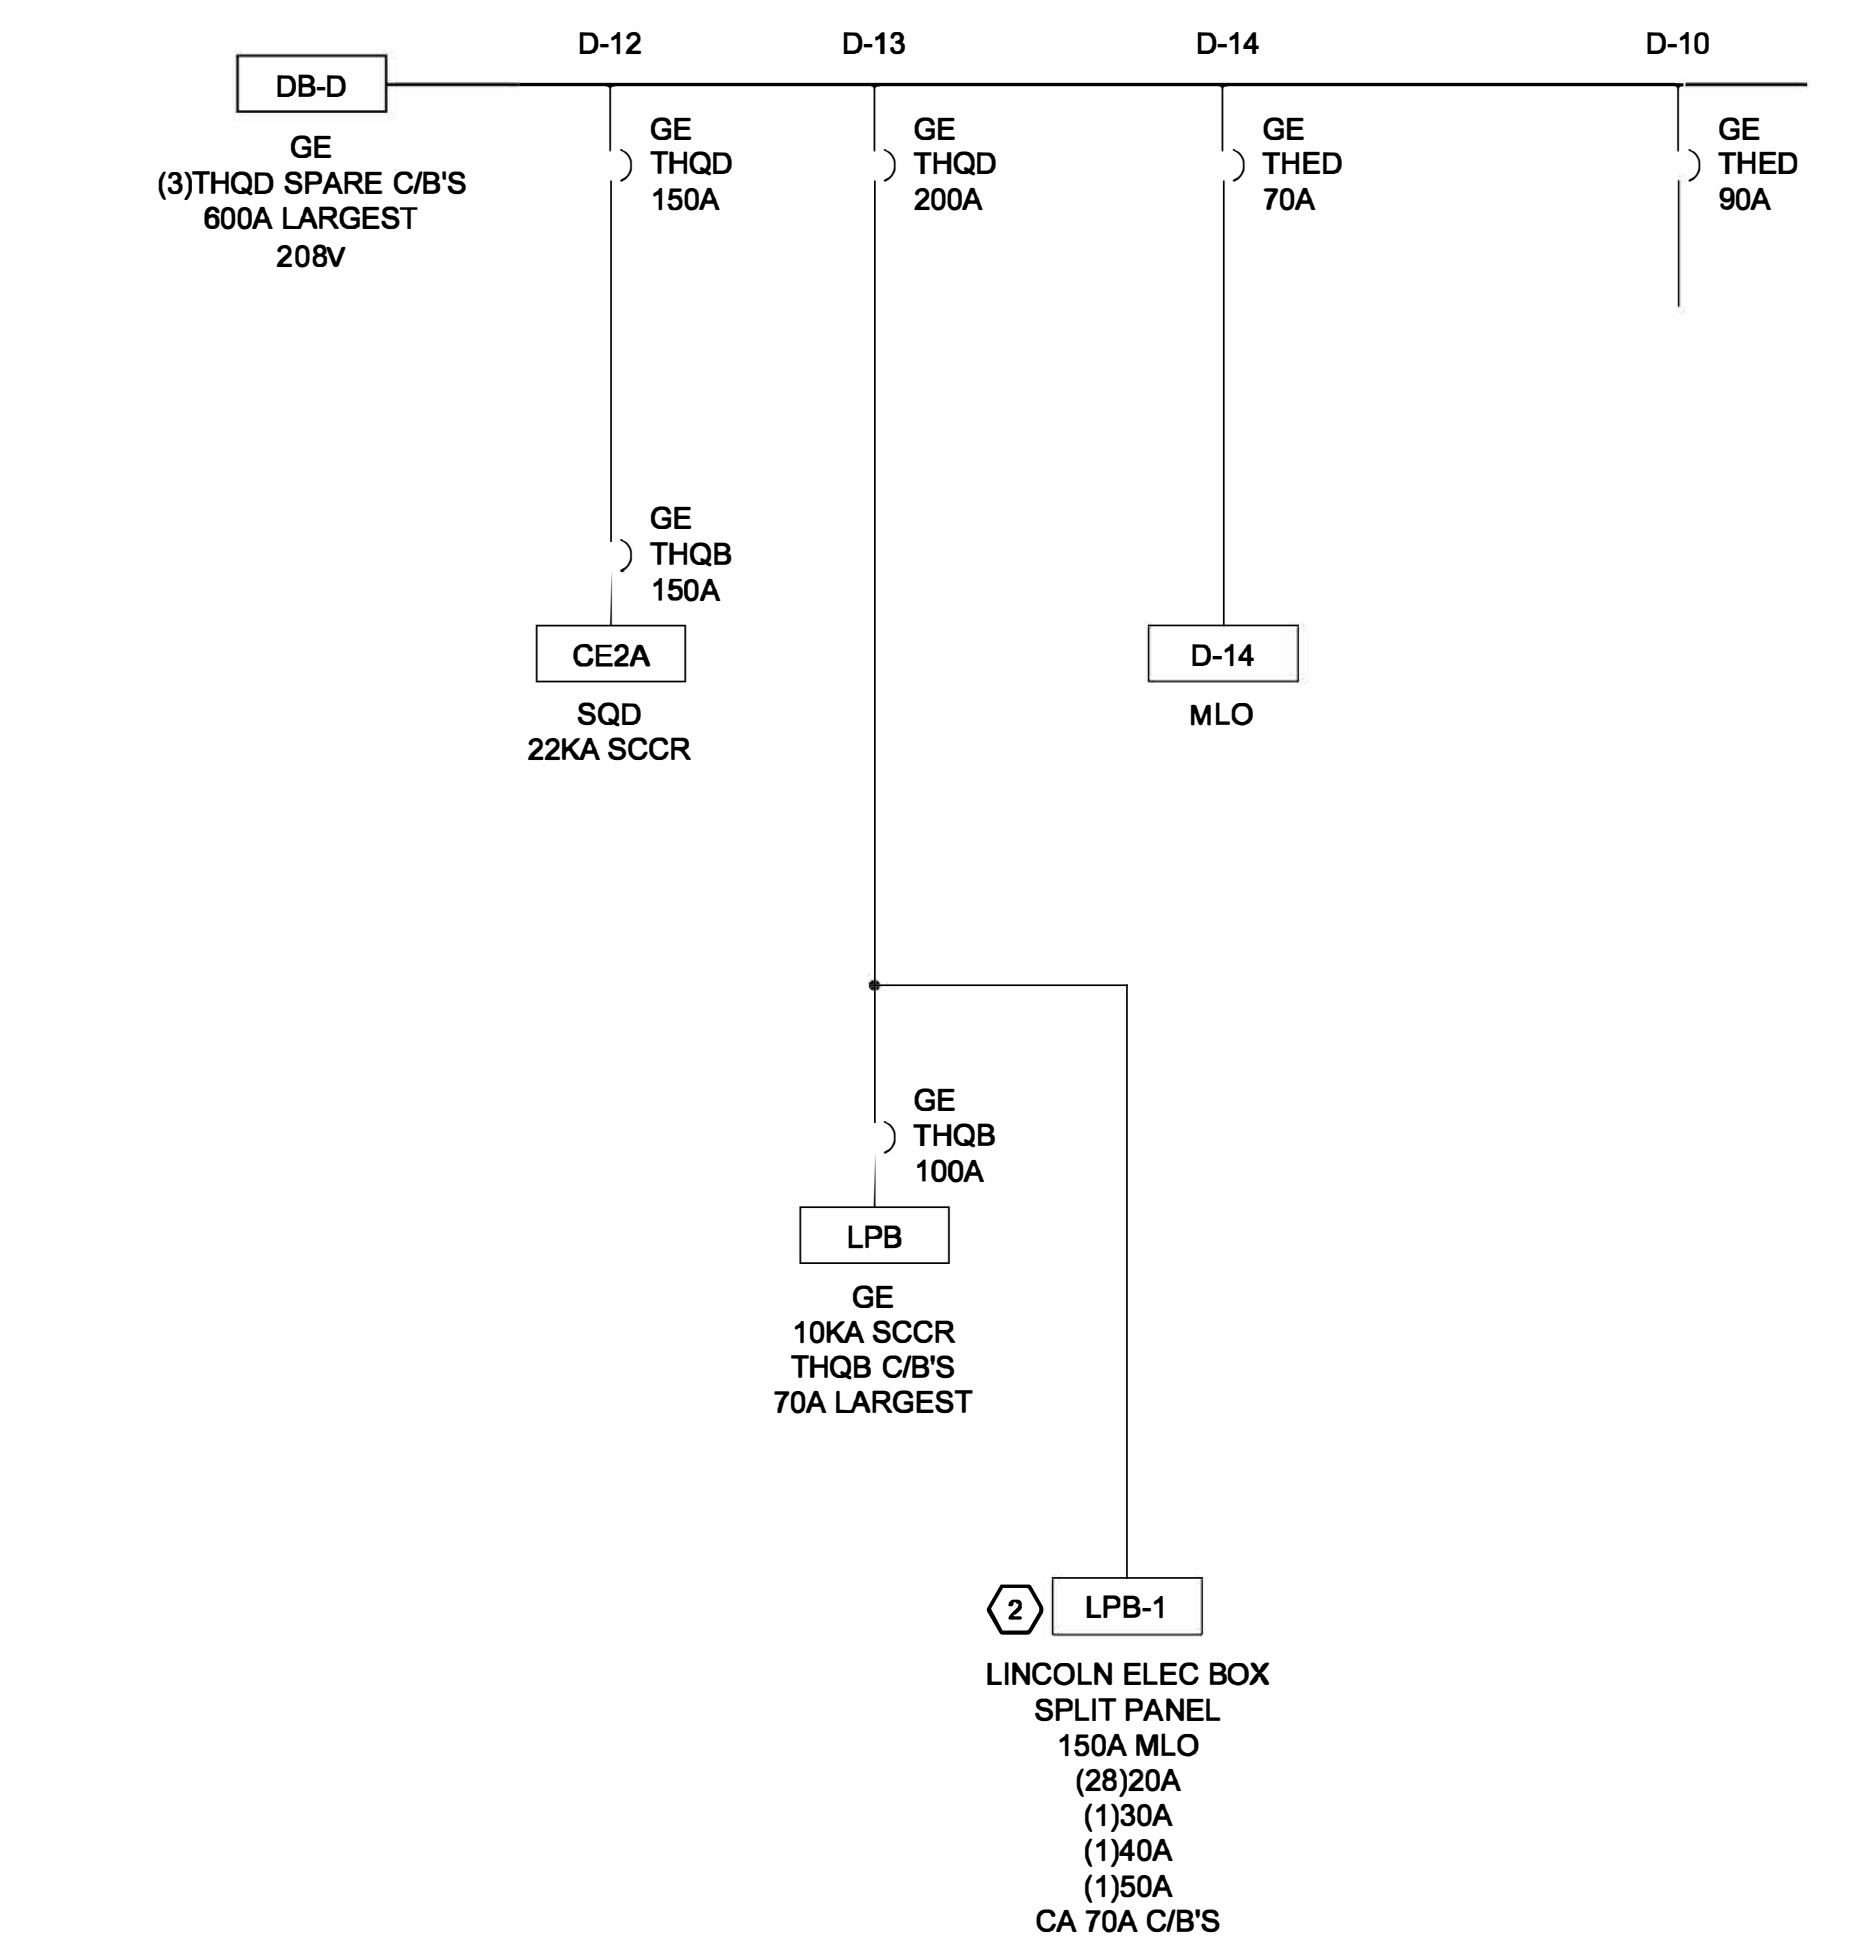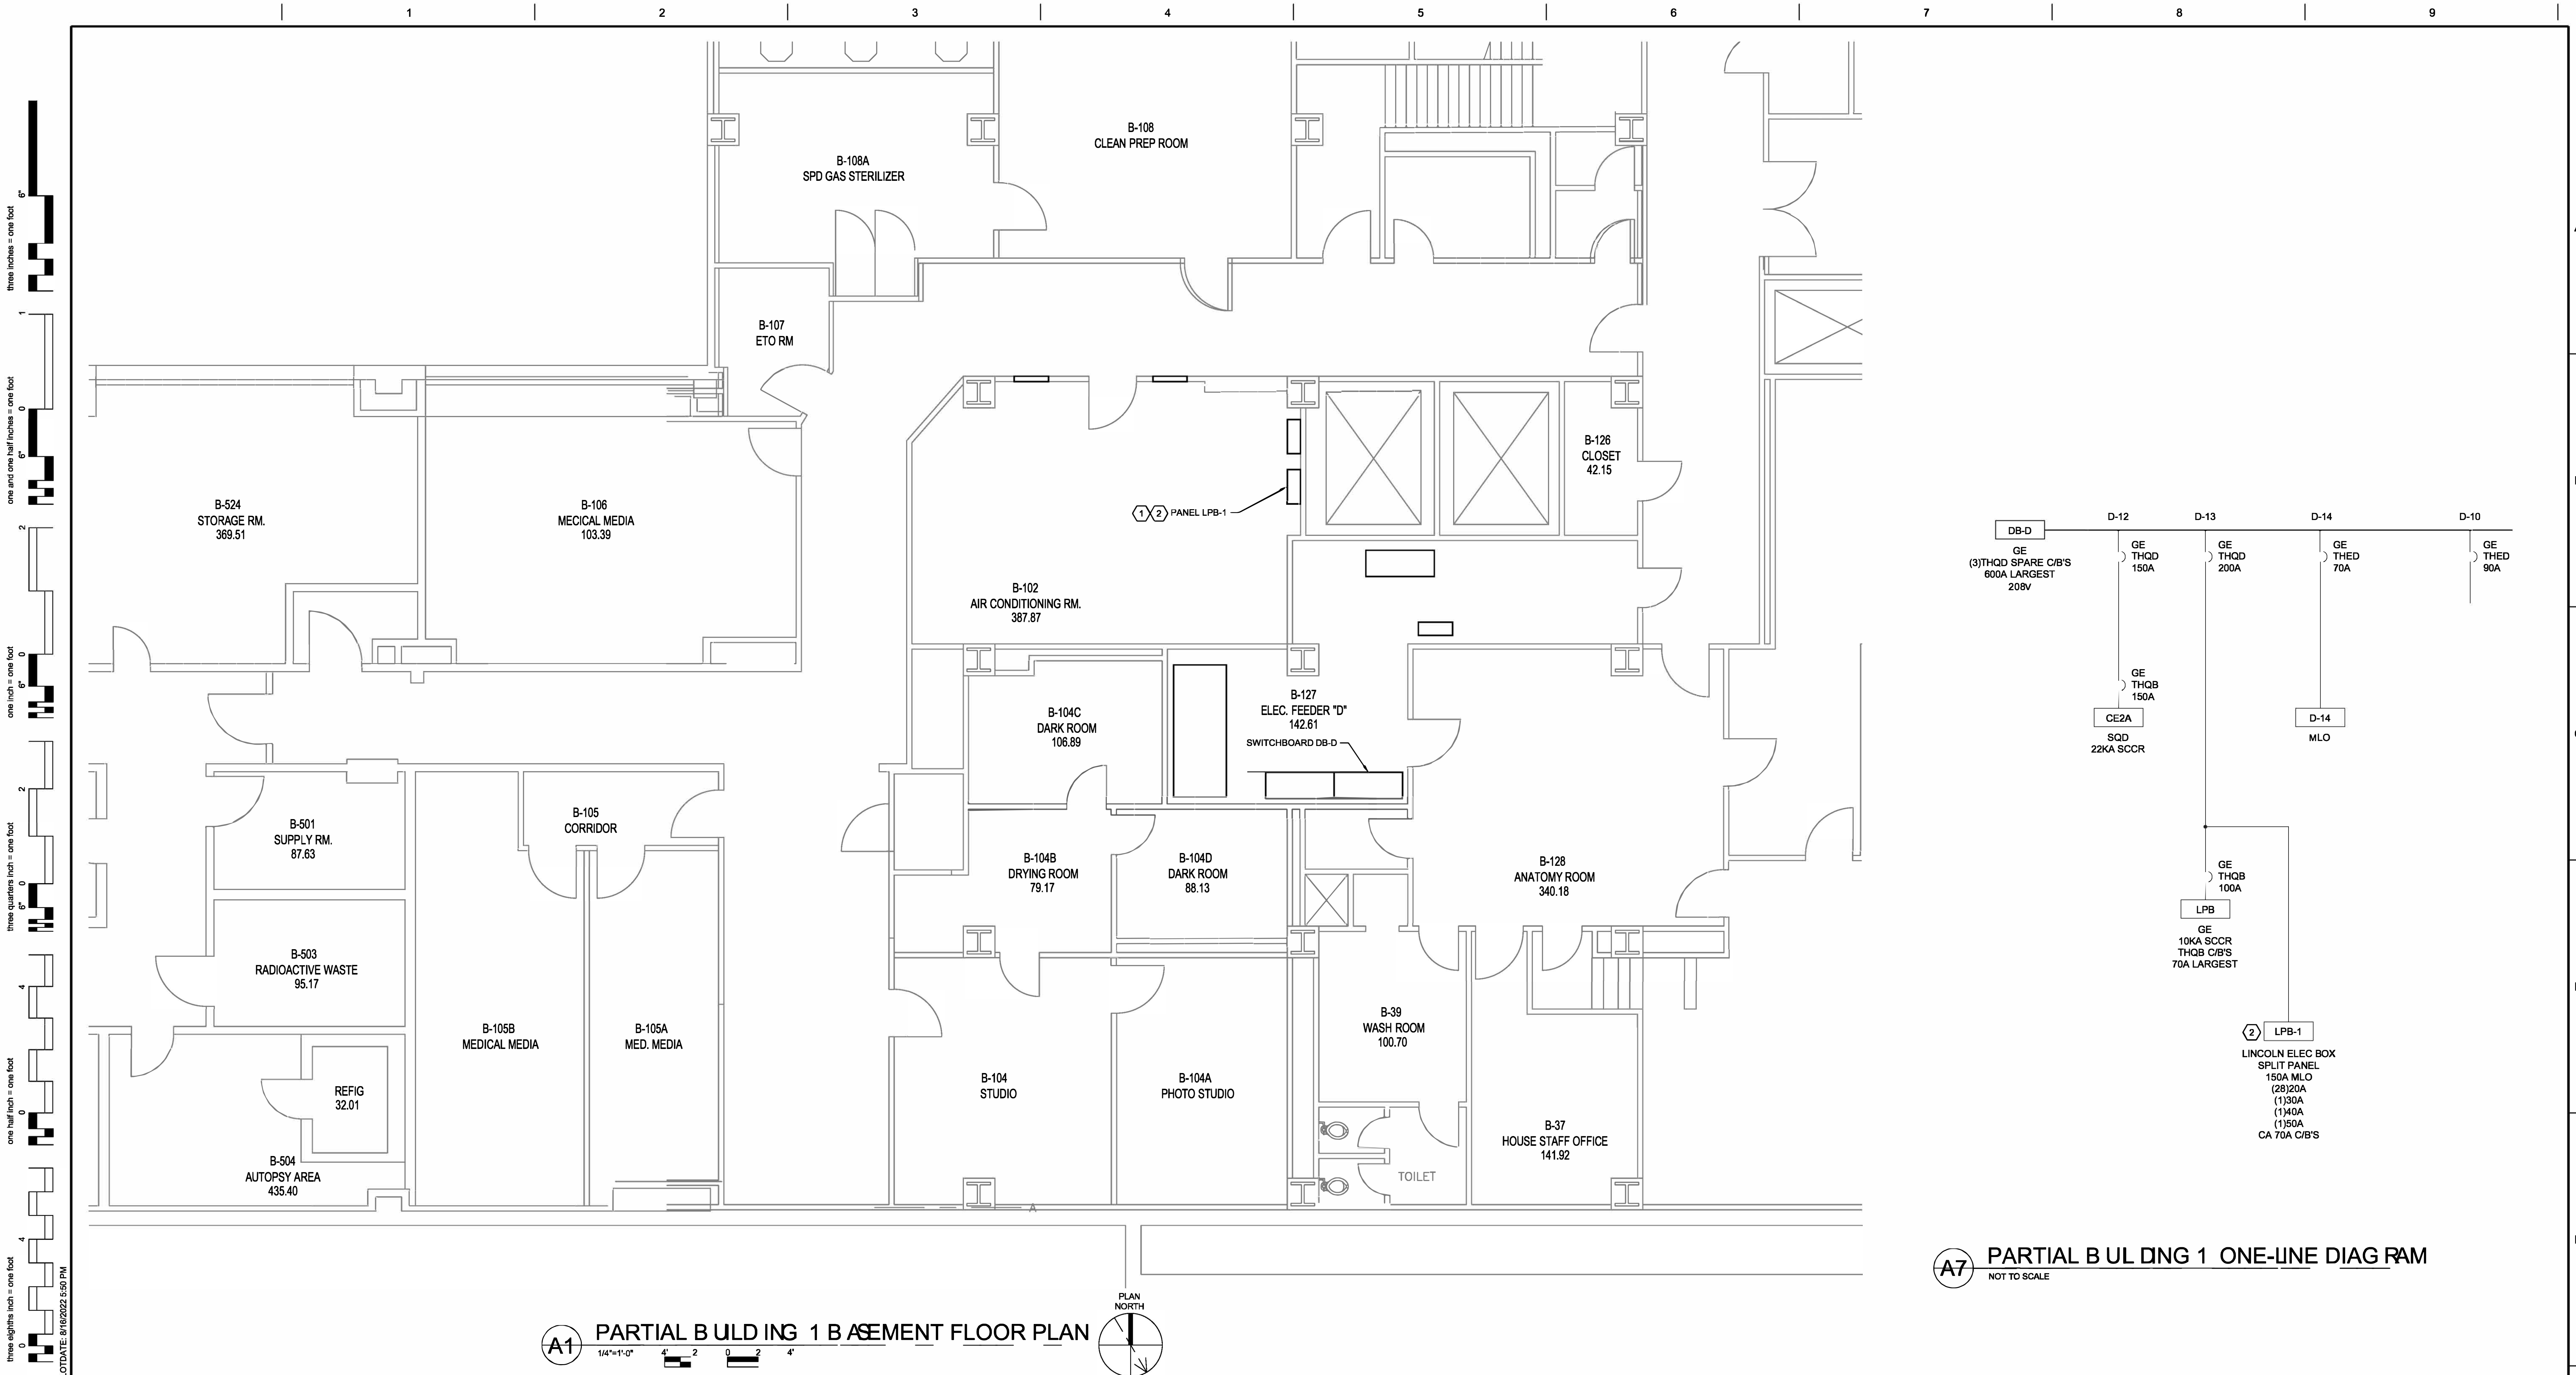

A7 PARTIAL BUILDING 1 ONE-LINE DIAGRAM
NOT TO SCALE

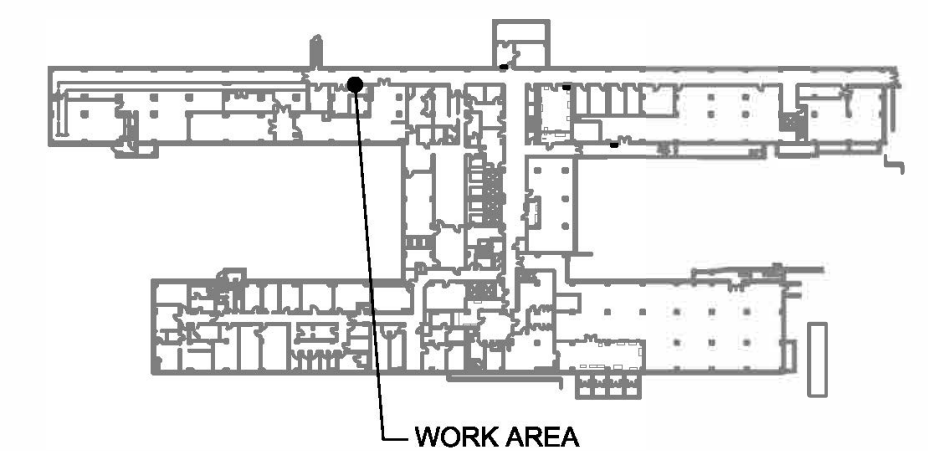

B1 - BASEMENT - KEY PLAN

DRAWING NOTES:


1. WORK SHOWN THIS DRAWING SHALL TAKE PLACE ON NIGHT/WEEKEND SHIFTS.

DRAWING KEYNOTES:

1. PROVIDE SINGLE POLE BLANK COVERS ON POLE POSITIONS 1, 4, AND 11. BLANK COVERS SHALL BE COMPATIBLE WITH EXISTING PANEL. PANEL INDICATED IS A LINCOLN ELECTRIC TYPE NQB PANEL..
2. DE-ENERGIZE, DISCONNECT, AND REMOVE (4) SINGLE PHASE 20A CIRCUIT BREAKERS IN POLE POSITIONS 3, 5, 19, AND 21. PROVIDE (2) 2-POLE 20A CIRCUIT BREAKER. CIRCUIT BREAKER SHALL BE COMPATIBLE EXISTING PANEL MANUFACTURER AND MATCH INTERRUPTING RATING.

CONSULTANTS:

RAMBOLL
RAMBOLL AMERICAS
ENGINEERING SOLUTIONS, INC.
 18 LINK DRIVE
 BINGHAM TOWN, NY 13902

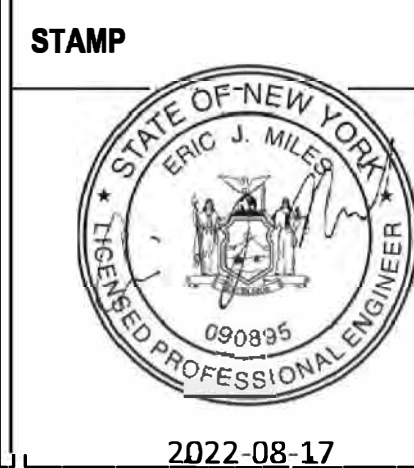

ARCHITECT/ENGINEERS:



D2X Associates

259 St. Ives Dr.
Talent, OR 97540

APPROVED BY:	VJC
--------------	-----

DATE:
08/24/22

Drawing Title	TASK ORDER 7
	BUILDING 1 PARTIAL BASEMENT PLAN PANEL LPB-1 AREA

Approved: Project Director

Project Title	UPGRADE LIFE SAFETY/CRITICAL BRANCH ELECTRICAL DISTRIBUTION NY HARBOR HEALTHCARE CENTER VA BROOKLYN CAMPUS
---------------	---

Issue Date	08/24/22
------------	----------

Checked	BKD
---------	-----


Drawn	KMB
-------	-----

Project Number	630A4-16-430
Building Number	1
Drawing Number	18-01-BK EP-170
Dwg. 75 of 91	

Office of
Construction
and Facilities
Management




three eighths inch = one foot
one and one half inches = one foot
one inch = one foot
three quarters inch = one foot
one half inch = one foot
three eighths inch = one foot
one quarter inch = one foot
one eighth inch = one foot

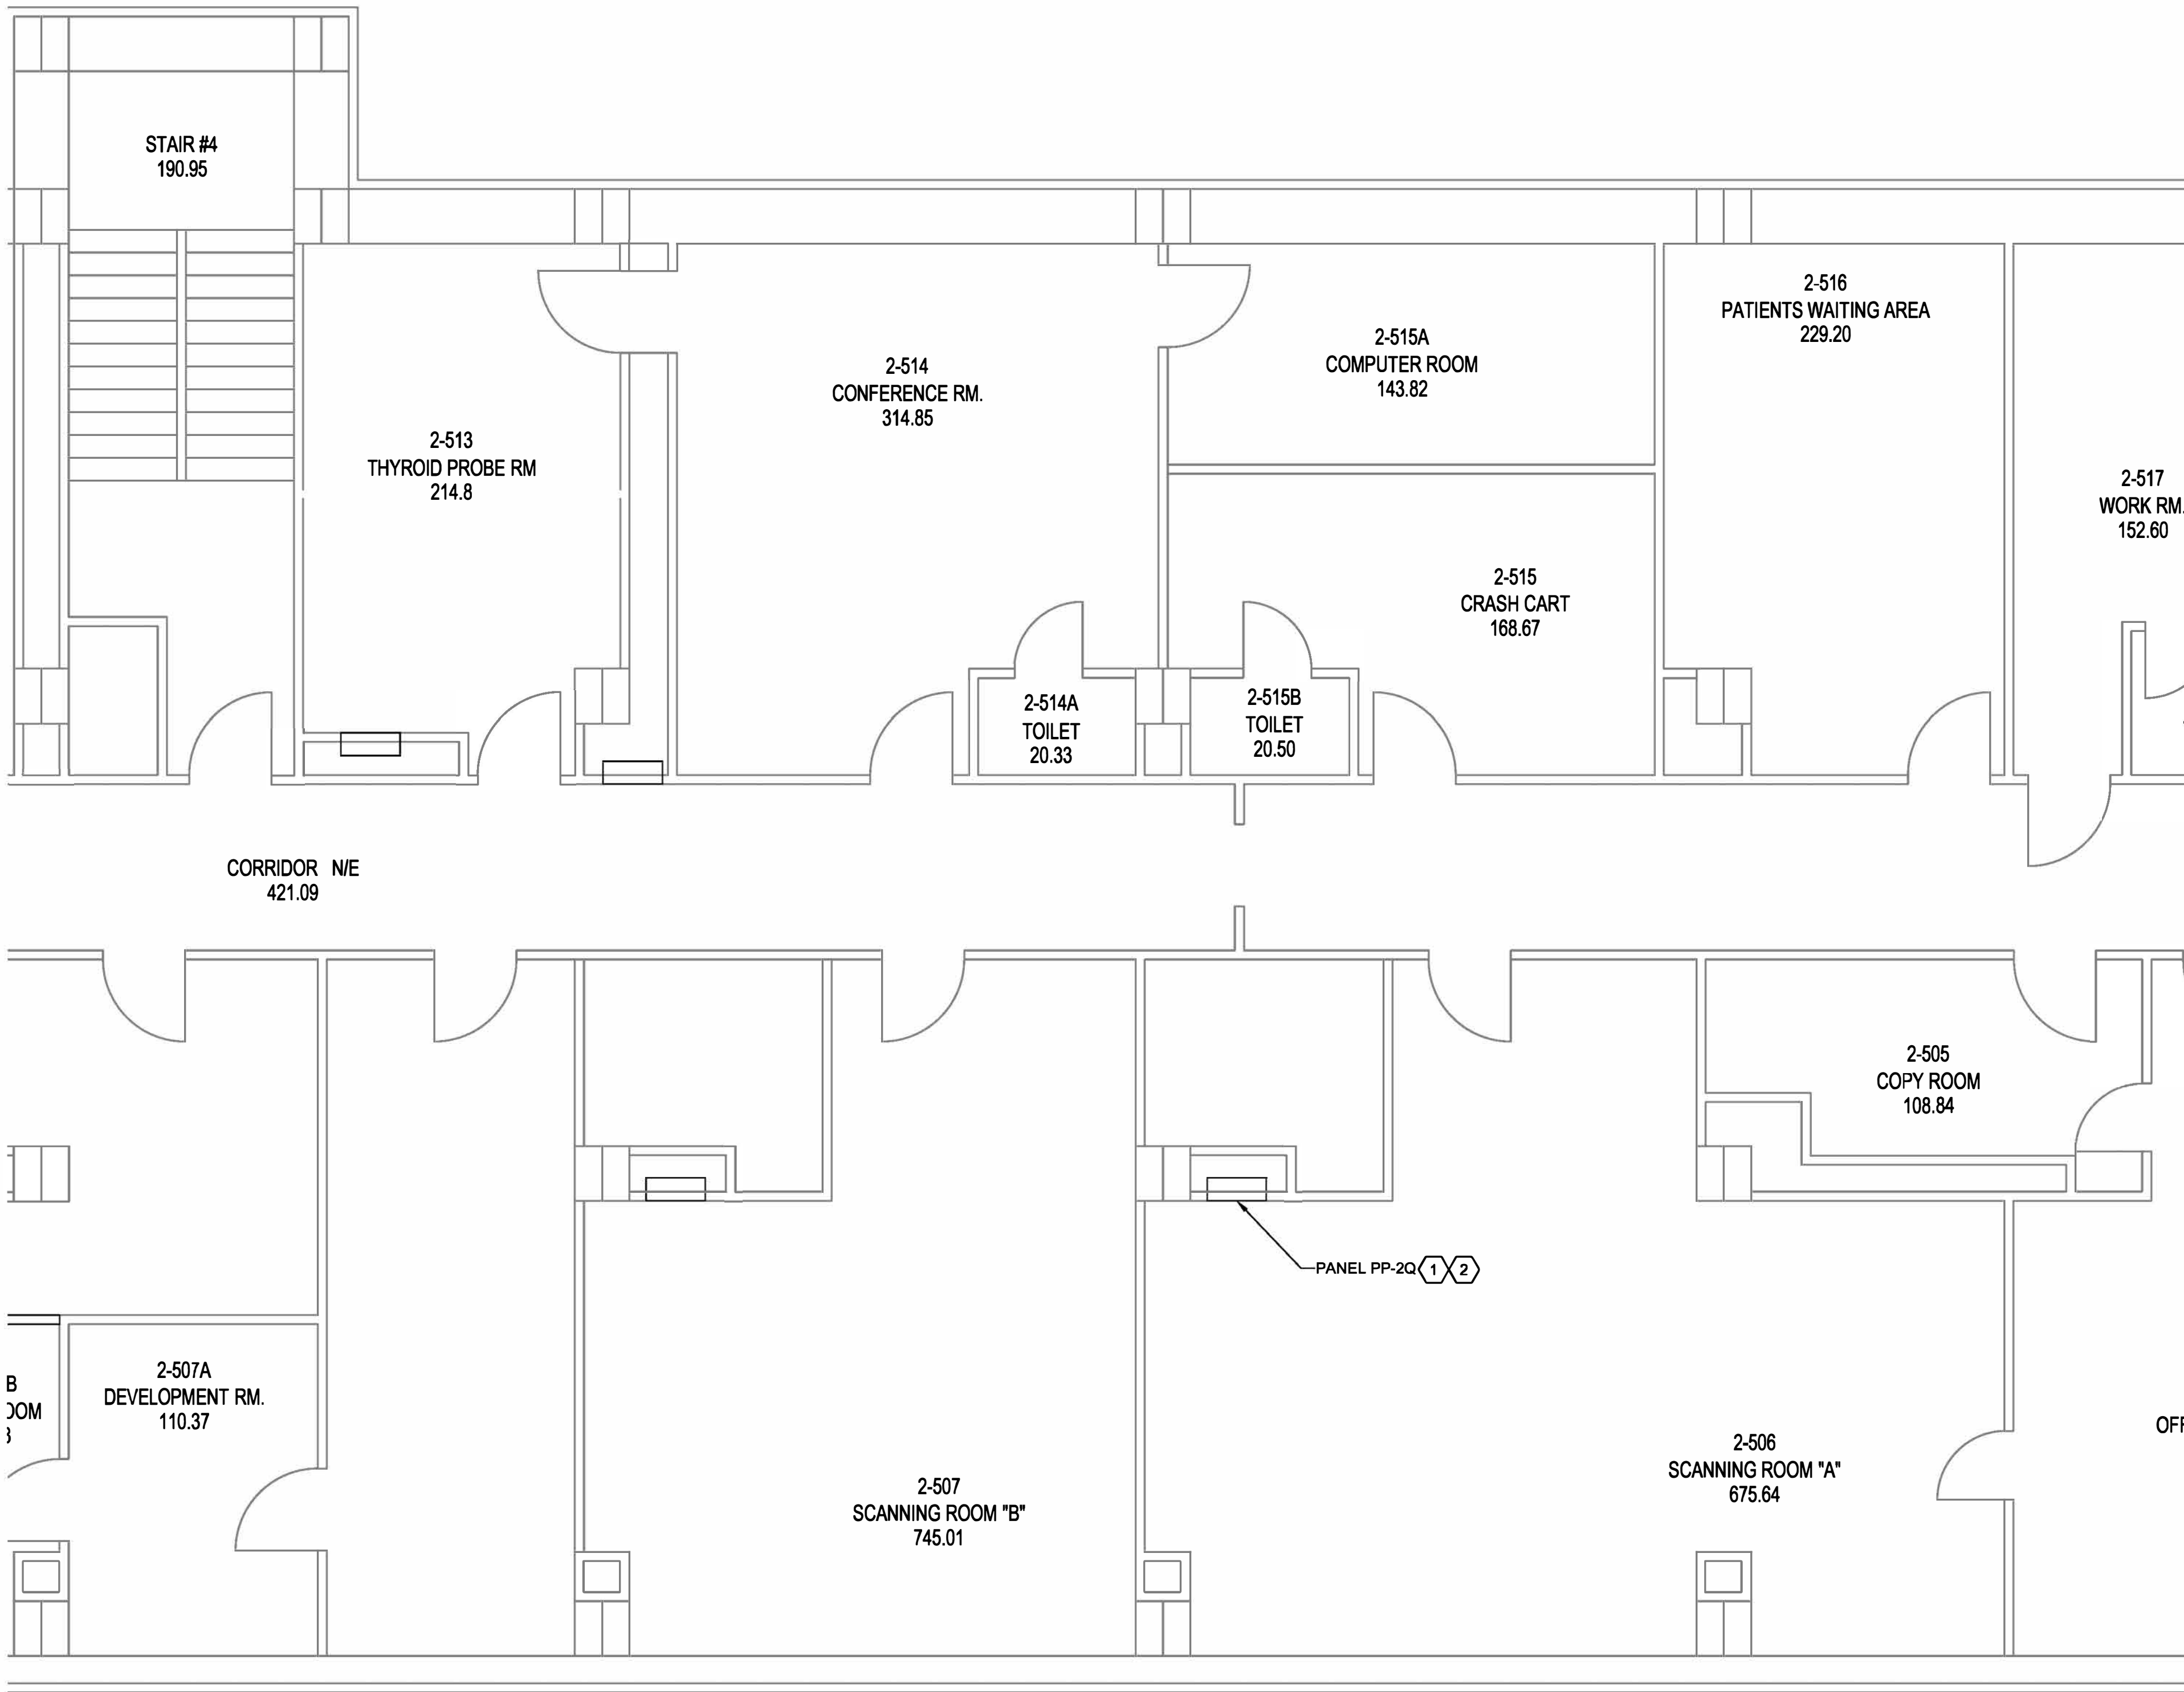

A1 PARTIAL BUILDING 1 SECOND FLOOR PLAN - PANEL PP-2Q WORK AREA

1/4"=1'-0"

4' 2' 0' 2' 4'

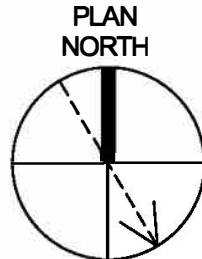


DRAWING NOTES:

- WORK SHOWN THIS DRAWING SHALL TAKE PLACE ON NIGHT/WEEKEND SHIFTS.
- PANEL DP-D IS IN THE BASEMENT IN FEEDER D ROOM B-127.
- PANEL PP-2Q HAS AN EXISTING ARC FLASH LABEL IDENTIFIED FOR PANEL PP-2R.


DRAWING KEYNOTES: (#)

- DE-ENERGIZE DISCONNECT AND REPLACE PANEL PP-2Q 150A 3-PHASE MAIN CIRCUIT BREAKER. CIRCUIT BREAKER SHALL MATCH EXISTING PANEL MANUFACTURER (SQUARE D TYPE NQOB) AND INTERRUPTING RATING.
- DISCONNECT AND REMOVE GROUNDED CONDUCTOR BONDED TO THE NEUTRAL TERMINAL STRIP. INTERCEPT AND EXTEND AS REQUIRED TO GROUNDING TERMINAL STRIP.

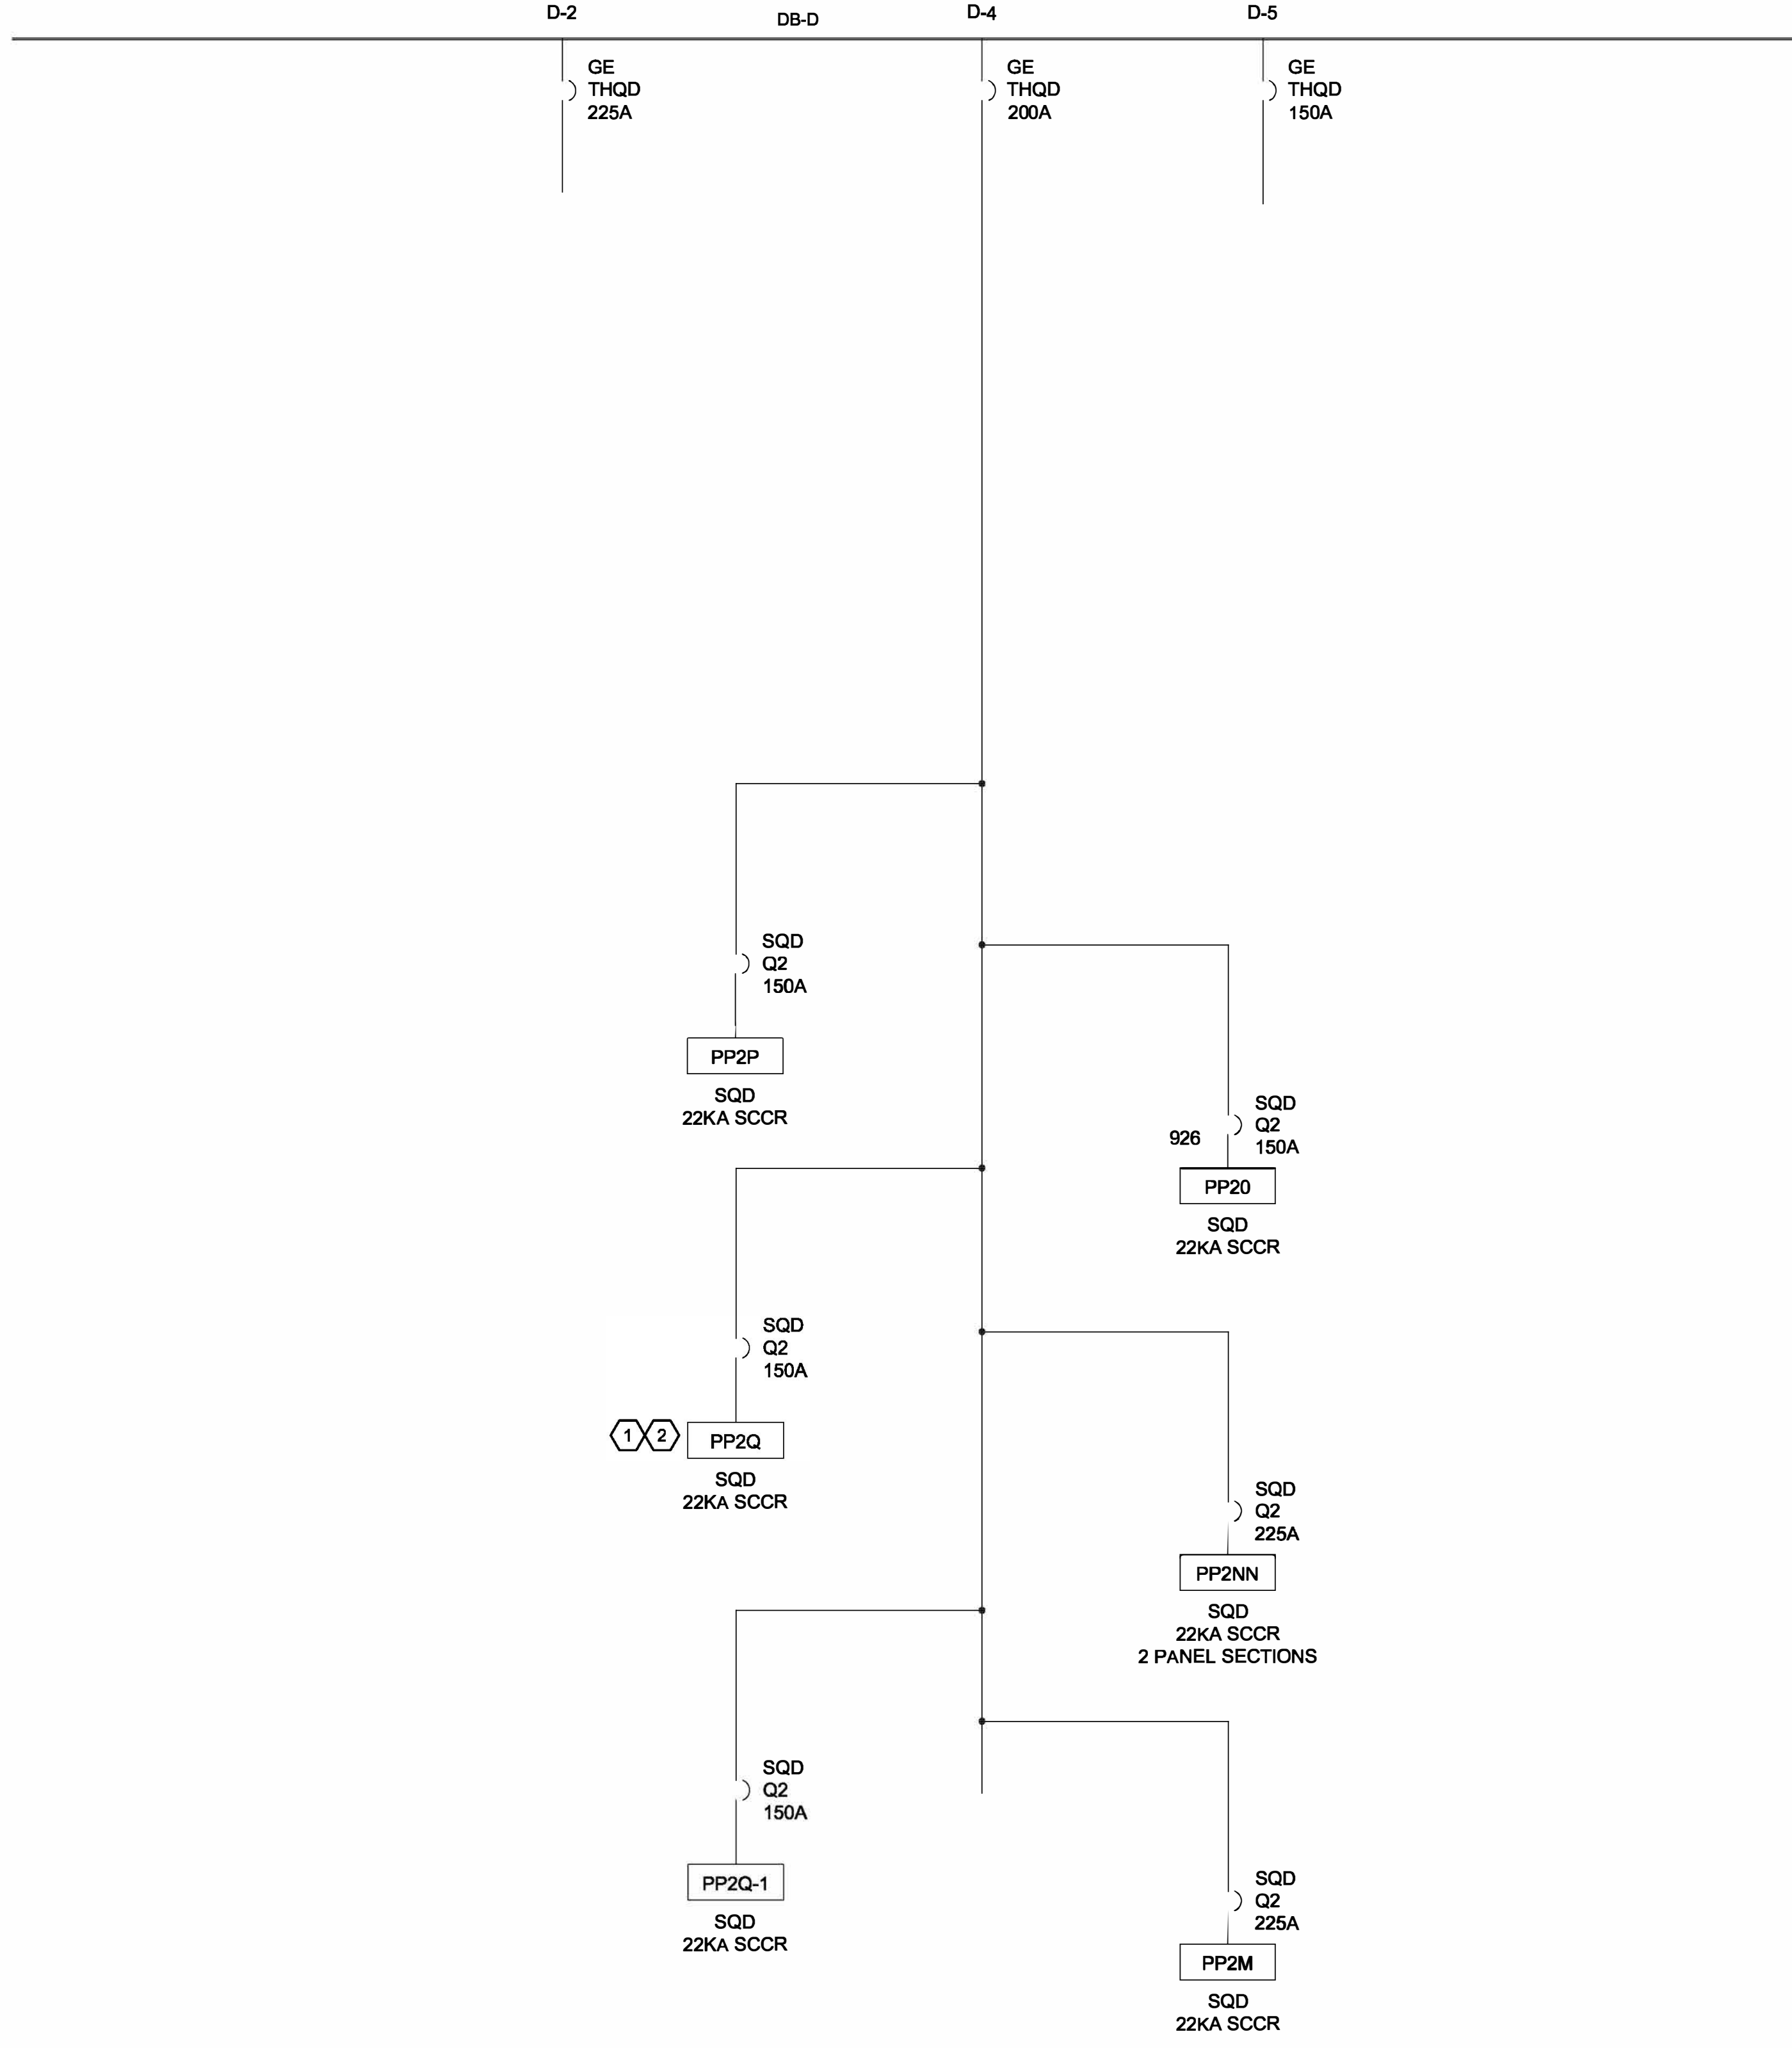

A6 PARTIAL BUILDING 1 ONE-LINE DIAGRAM


NOT TO SCALE

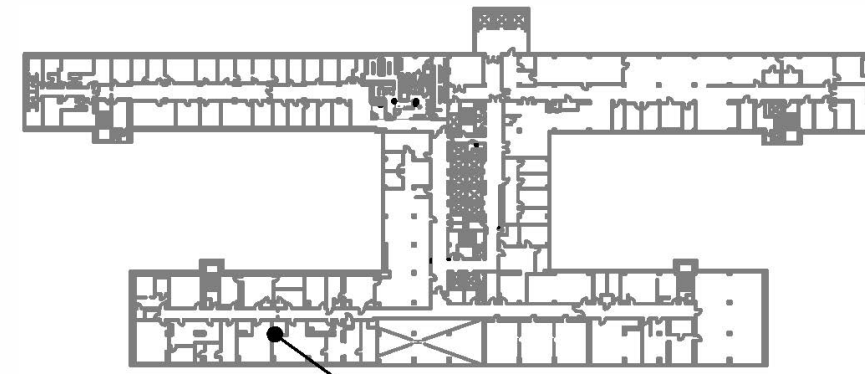


B1 - 2ND FL - KEY PLAN

 
NOT TO SCALE



		CONSULTANTS:		STAMP		ARCHITECT/ENGINEERS:		APPROVED BY: VJC		DATE: 08/24/22		Drawing Title TASK ORDER 10 BUILDING 1 PARTIAL 2ND FLOOR PLAN PANEL PP-2Q AREA		Project Title UPGRADE LIFE SAFETY/CRITICAL BRANCH ELECTRICAL DISTRIBUTION NY HARBOR HEALTHCARE CENTER VA BROOKLYN CAMPUS		Project Number 630A4-16-430		Office of Construction and Facilities Management			
		RAMBOLL RAMBOLL AMERICAS ENGINEERING SOLUTIONS, INC. 18 LINK DRIVE BINGHAMTON, NY 13902				 259 St. Ives Dr. Talent, OR 97540						Approved: Project Director		Location 800 POLY PLACE, BROOKLYN NY 11209		Drawing Number 18-01-BK EP-172					
REV. 0 ISSUED FOR CONSTRUCTION		08/24/22				2022-08-17								Issue Date 08/24/22		Checked BKD		Drawn KMB		Dwg. 77 of 91	
Revisions:		Date																		 Department of Veterans Affairs	

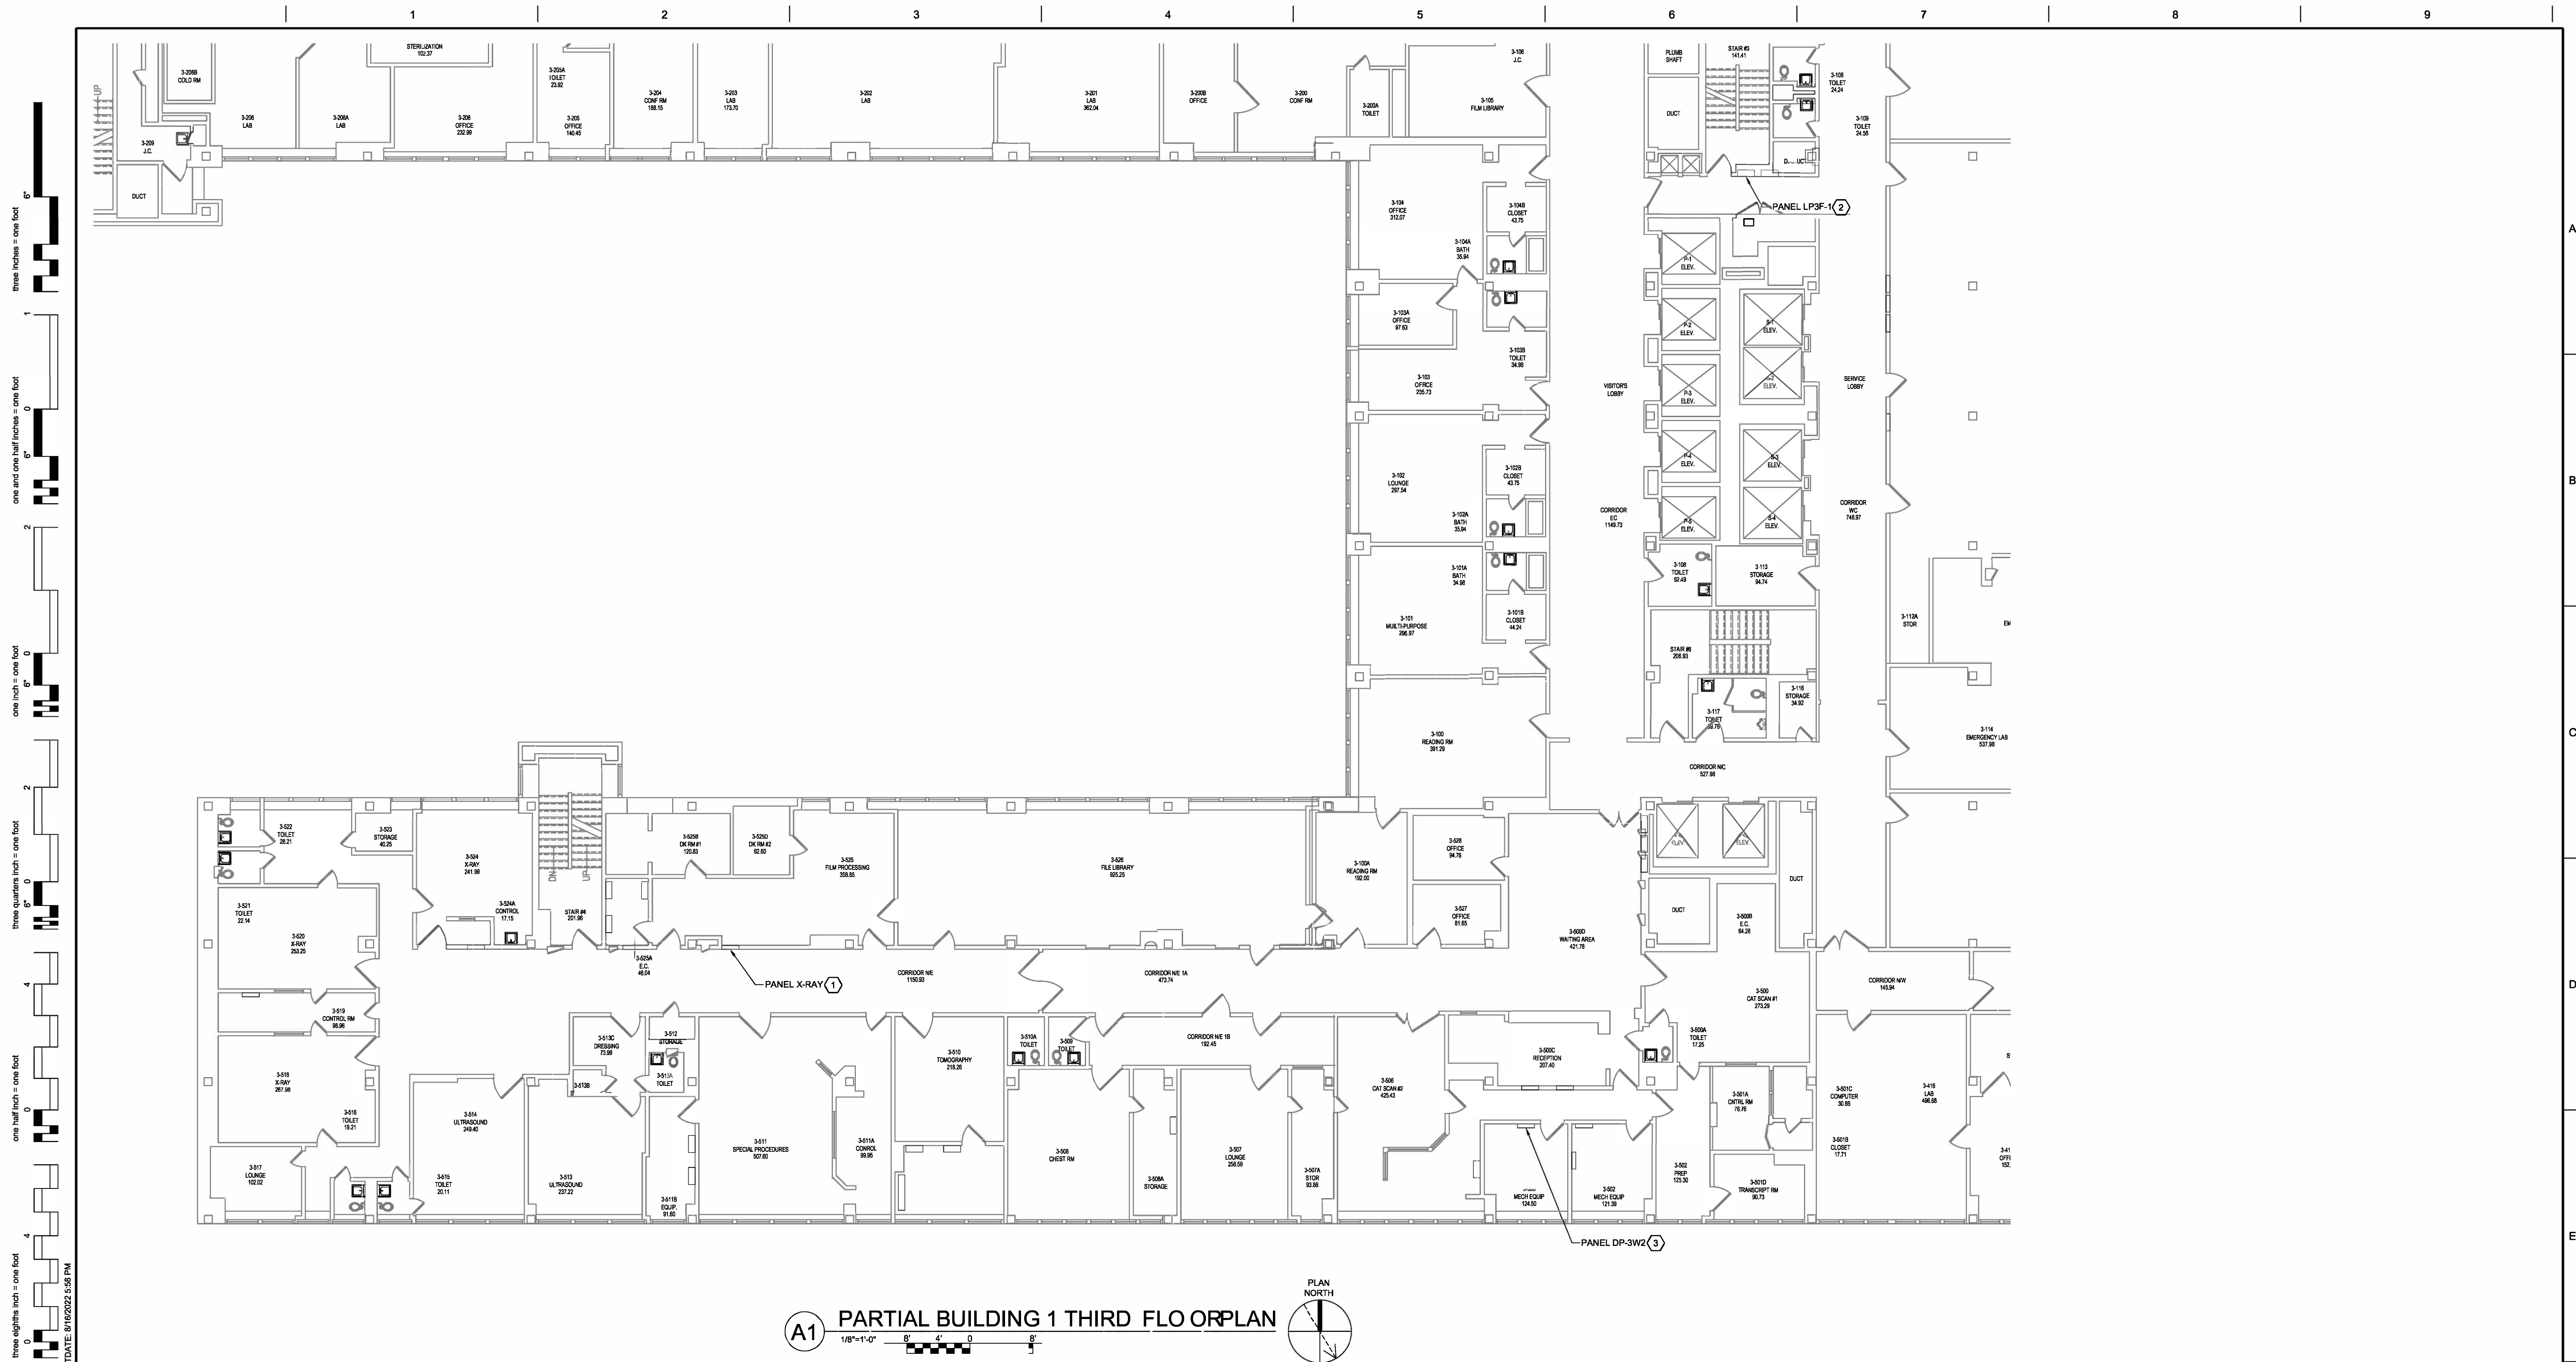


A1 PARTIAL BUILDING 1 THIRD FLOOR PLAN

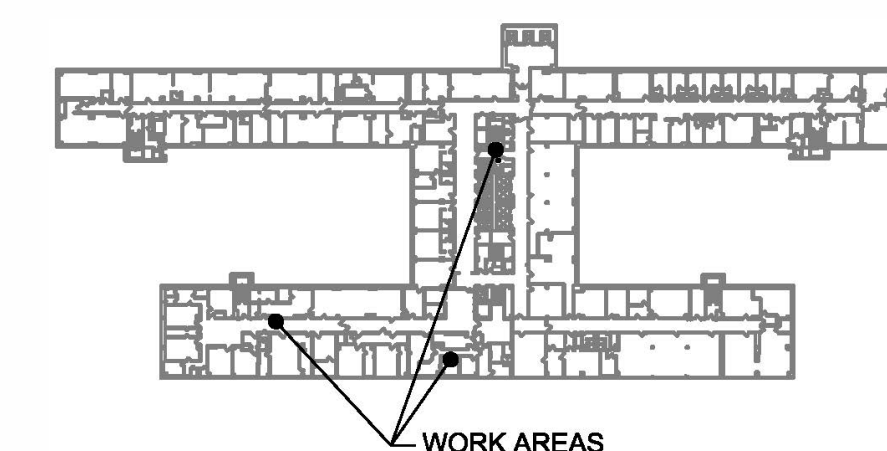DRAWING KEYNOTES: #


B1 - 3RD FL - KEY PLAN
NOT TO SCALE

[illegible]


three inches = one foot
one and one half inches = one foot
one inch = one foot
three quarters inch = one foot
one half inch = one foot
three eighths inch = one foot
one quarter inch = one foot
one eighth inch = one foot

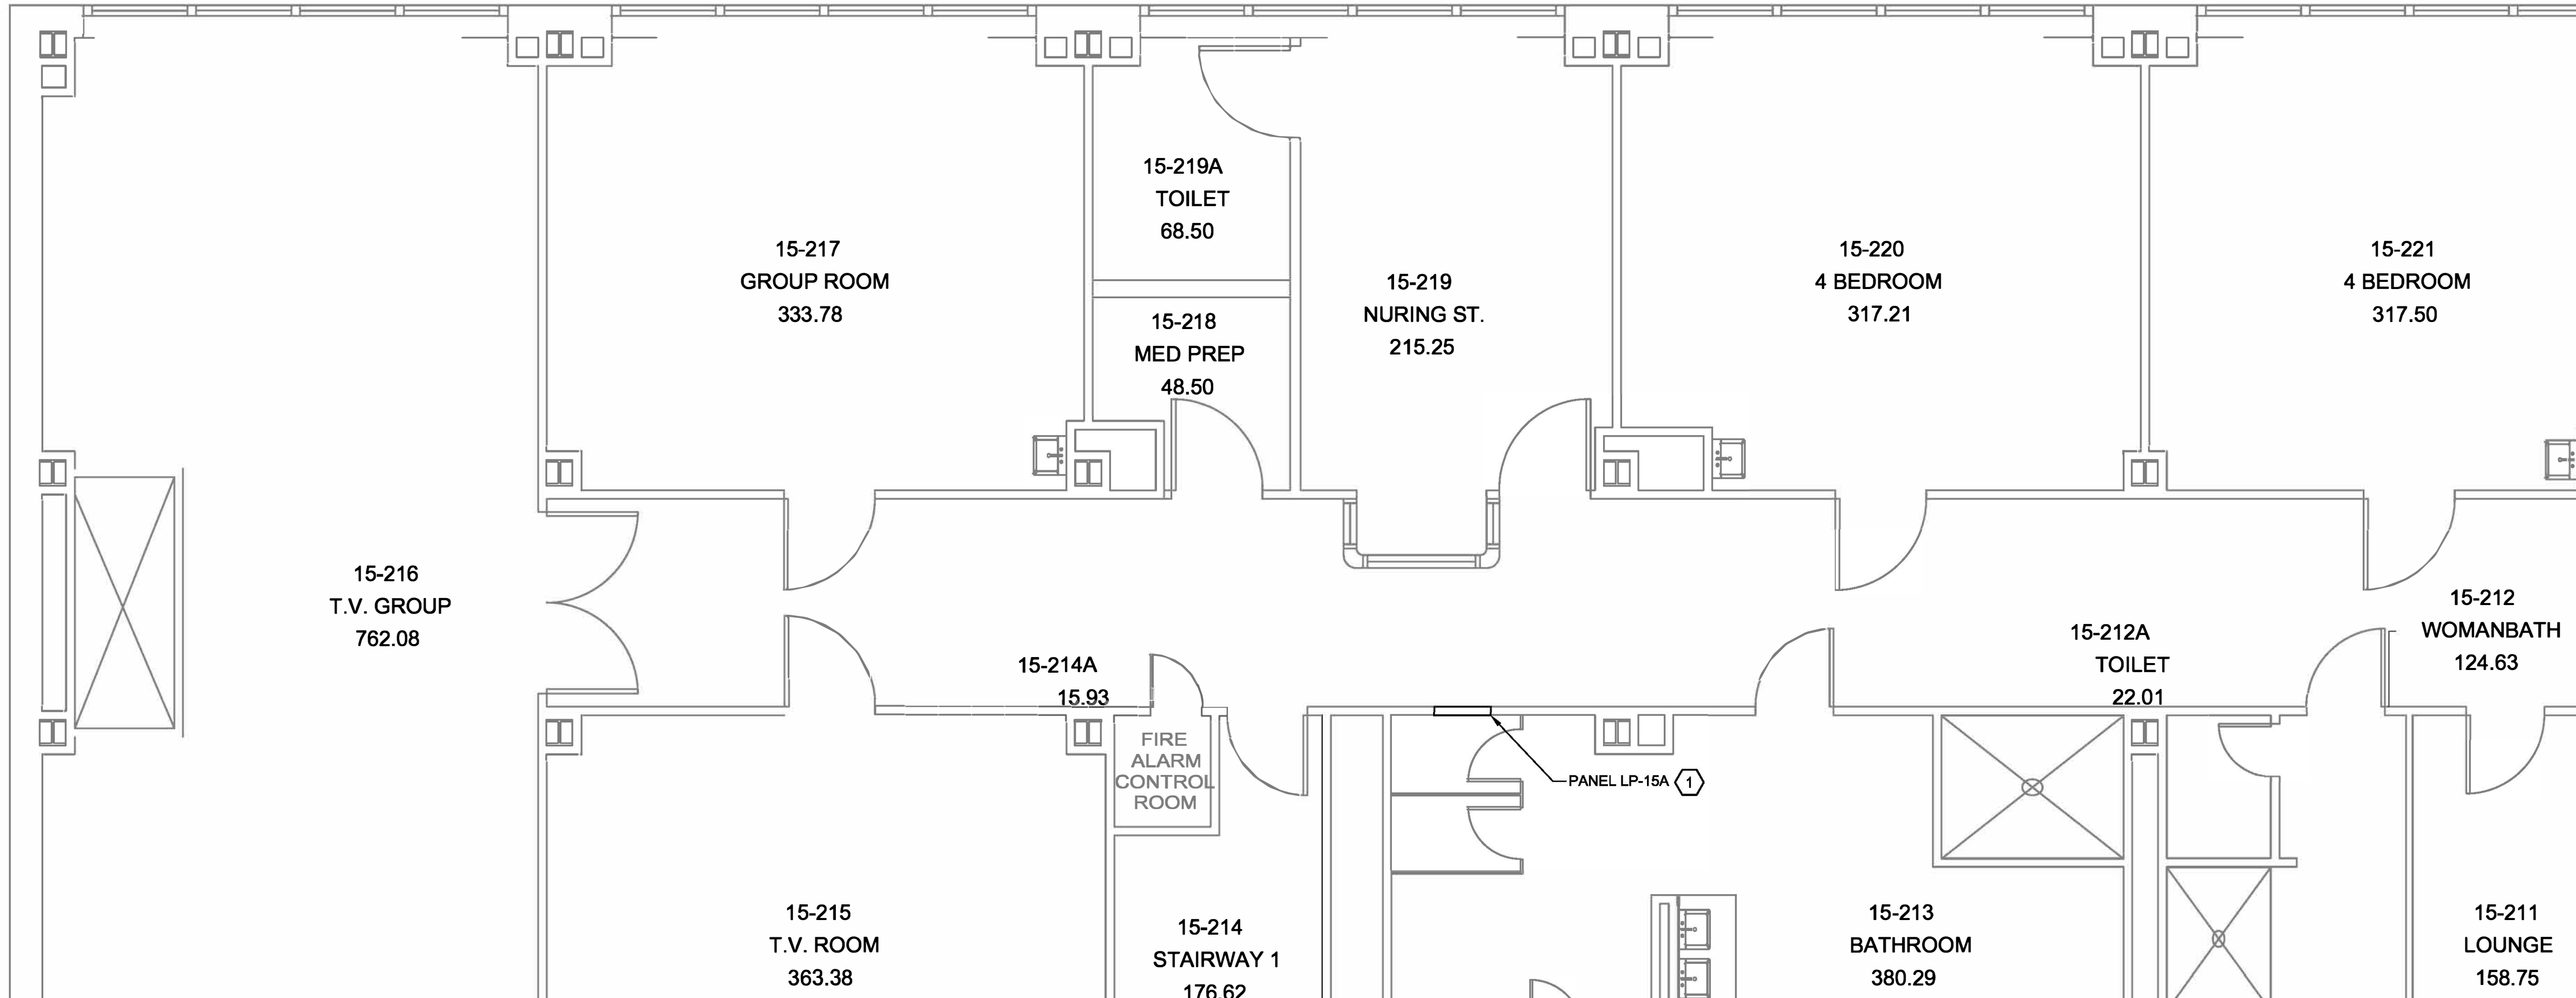


A1 PARTIAL BUILDING 1 FIFTEENTH FLOOR PLAN - PANEL LP-15A WORK AREA

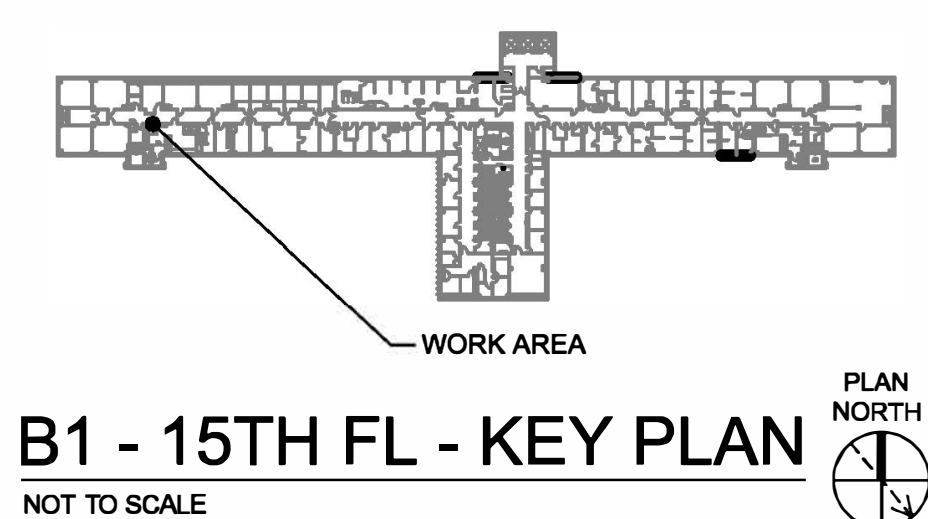

B1 - 15TH FL - KEY PLAN
NOT TO SCALE

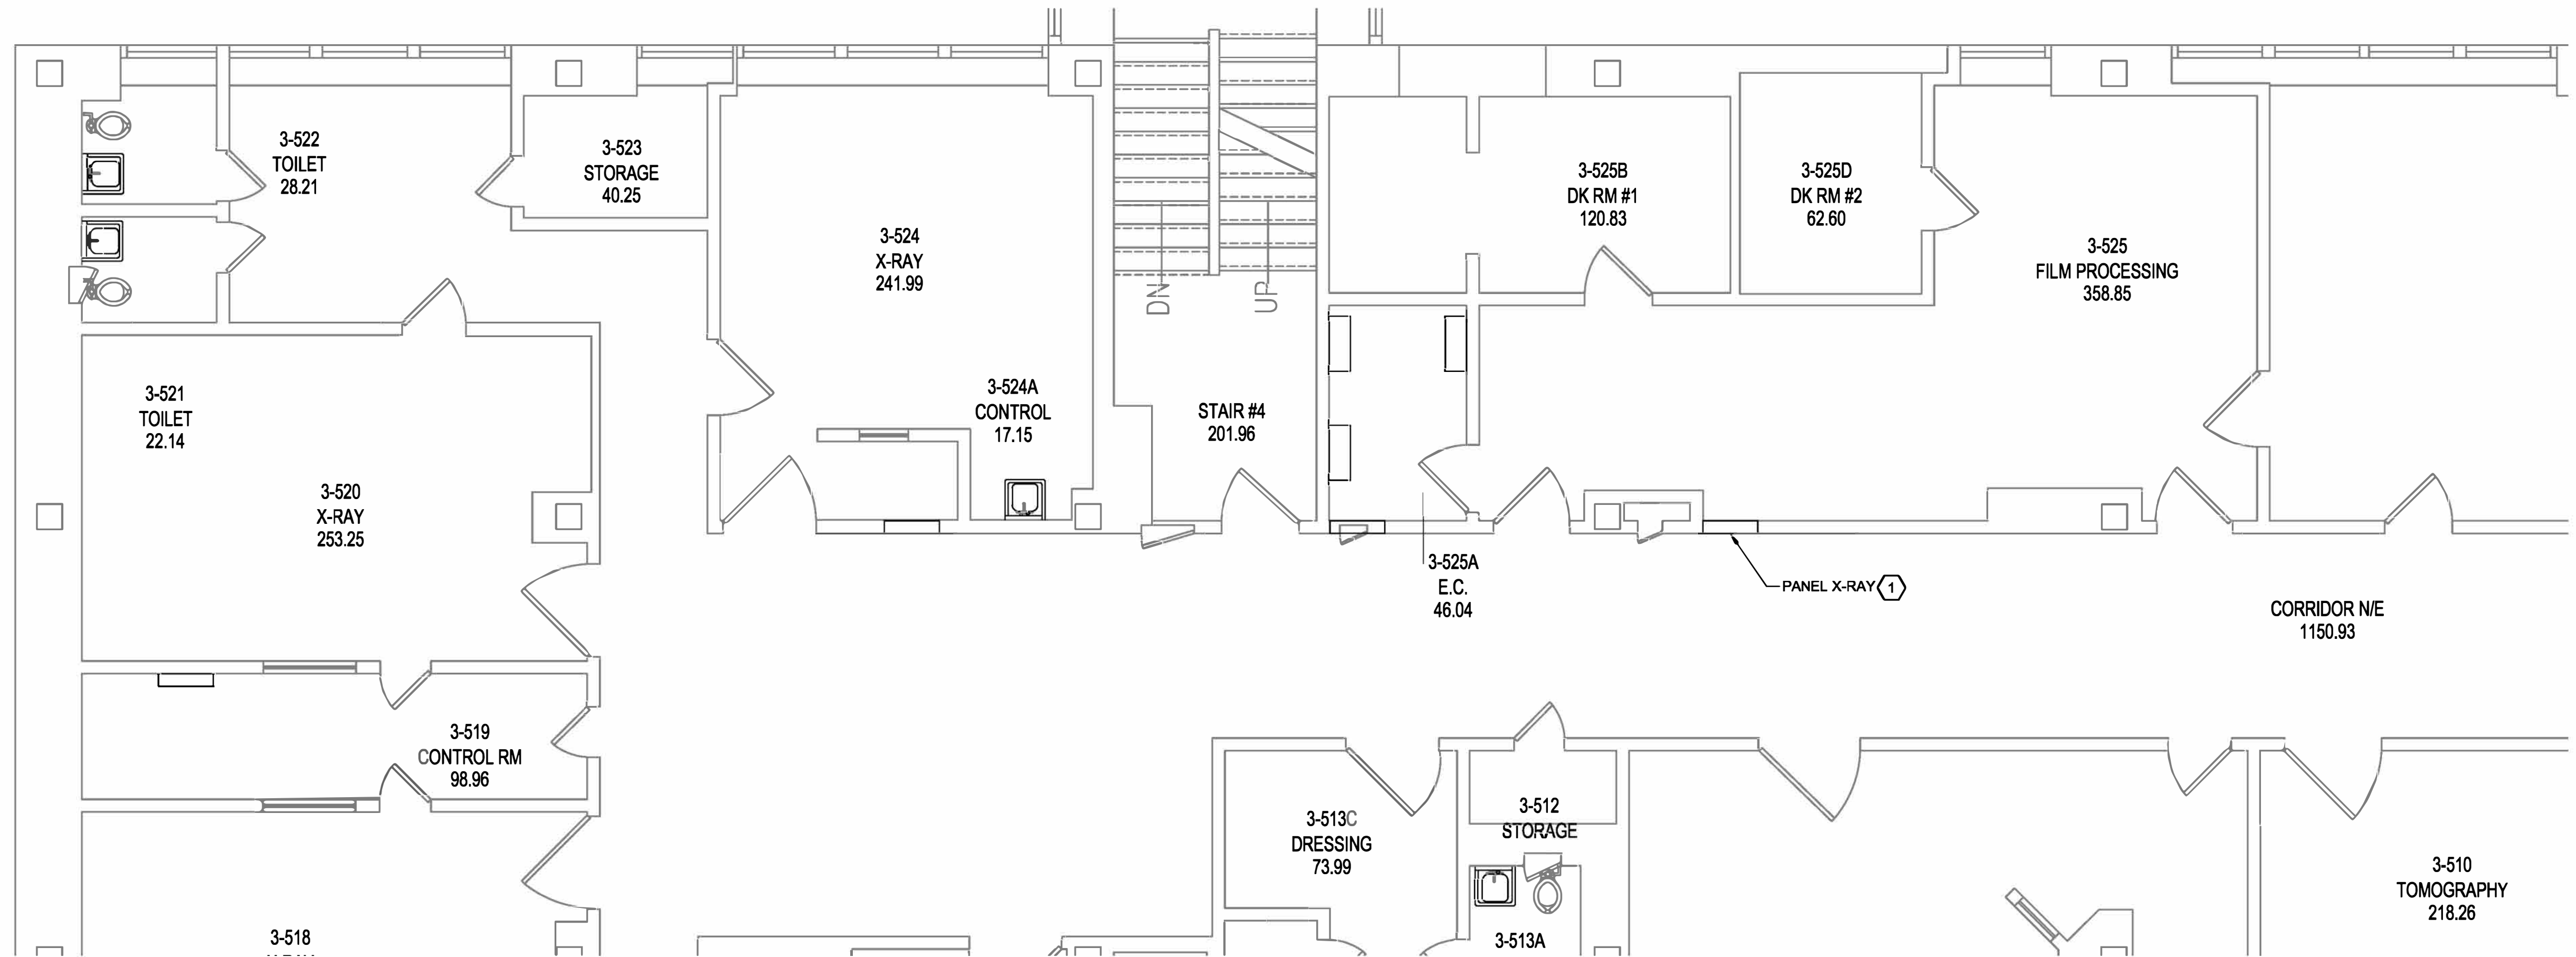

D1 PARTIAL BUILDING 1 THIRD FLOOR PLAN - PANEL X-RAY WORK AREA

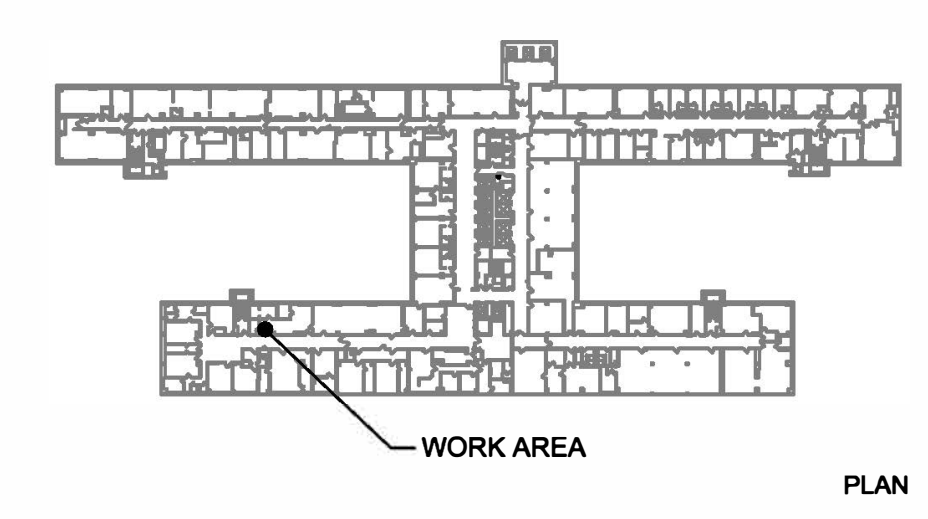

B1 - 4TH FL - KEY PLAN
NOT TO SCALE

DRAWING KEYNOTES: 1. PROVIDE LOCK ON POWER PANEL INDICATED. COORDINATE EXACT LOCK STYLE WITH THE VA PRIOR TO BID.

REV. 0 ISSUED FOR CONSTRUCTION	08/24/22
Revisions:	Date

CONSULTANTS:

RAMBOLL
RAMBOLL AMERICAS
ENGINEERING SOLUTIONS, INC.
18 LINK DRIVE
BINGHAMTON, NY 13902



ARCHITECT/ENGINEERS:

D2X Associates
259 St. Ives Dr.
Talent, OR 97540

APPROVED BY: VJC
DATE: 08/24/22


Drawing Title
**TASK ORDER 14
BUILDING 1 PARTIAL FLOOR PLANS
PANEL X-RAY AND LP-15A AREAS**
Approved: Project Director

Project Title
UPGRADE LIFE SAFETY/CRITICAL BRANCH
ELECTRICAL DISTRIBUTION
NY HARBOR HEALTHCARE CENTER
VA BROOKLYN CAMPUS
Location 800 POLY PLACE, BROOKLYN NY 11209
Issue Date 08/24/22
Checked BKD
Drawn KMB

Project Number 630A4-16-430
Building Number 1
Drawing Number 18-01-BK
EP-175
Dwg. 80 of 91



Office of
Construction
and Facilities
Management
Department of
Veterans Affairs

three inches = one foot
one and one half inches = one foot
one inch = one foot
three quarters inch = one foot
one half inch = one foot
three eighths inch = one foot
one quarter inch = one foot
one eighth inch = one foot

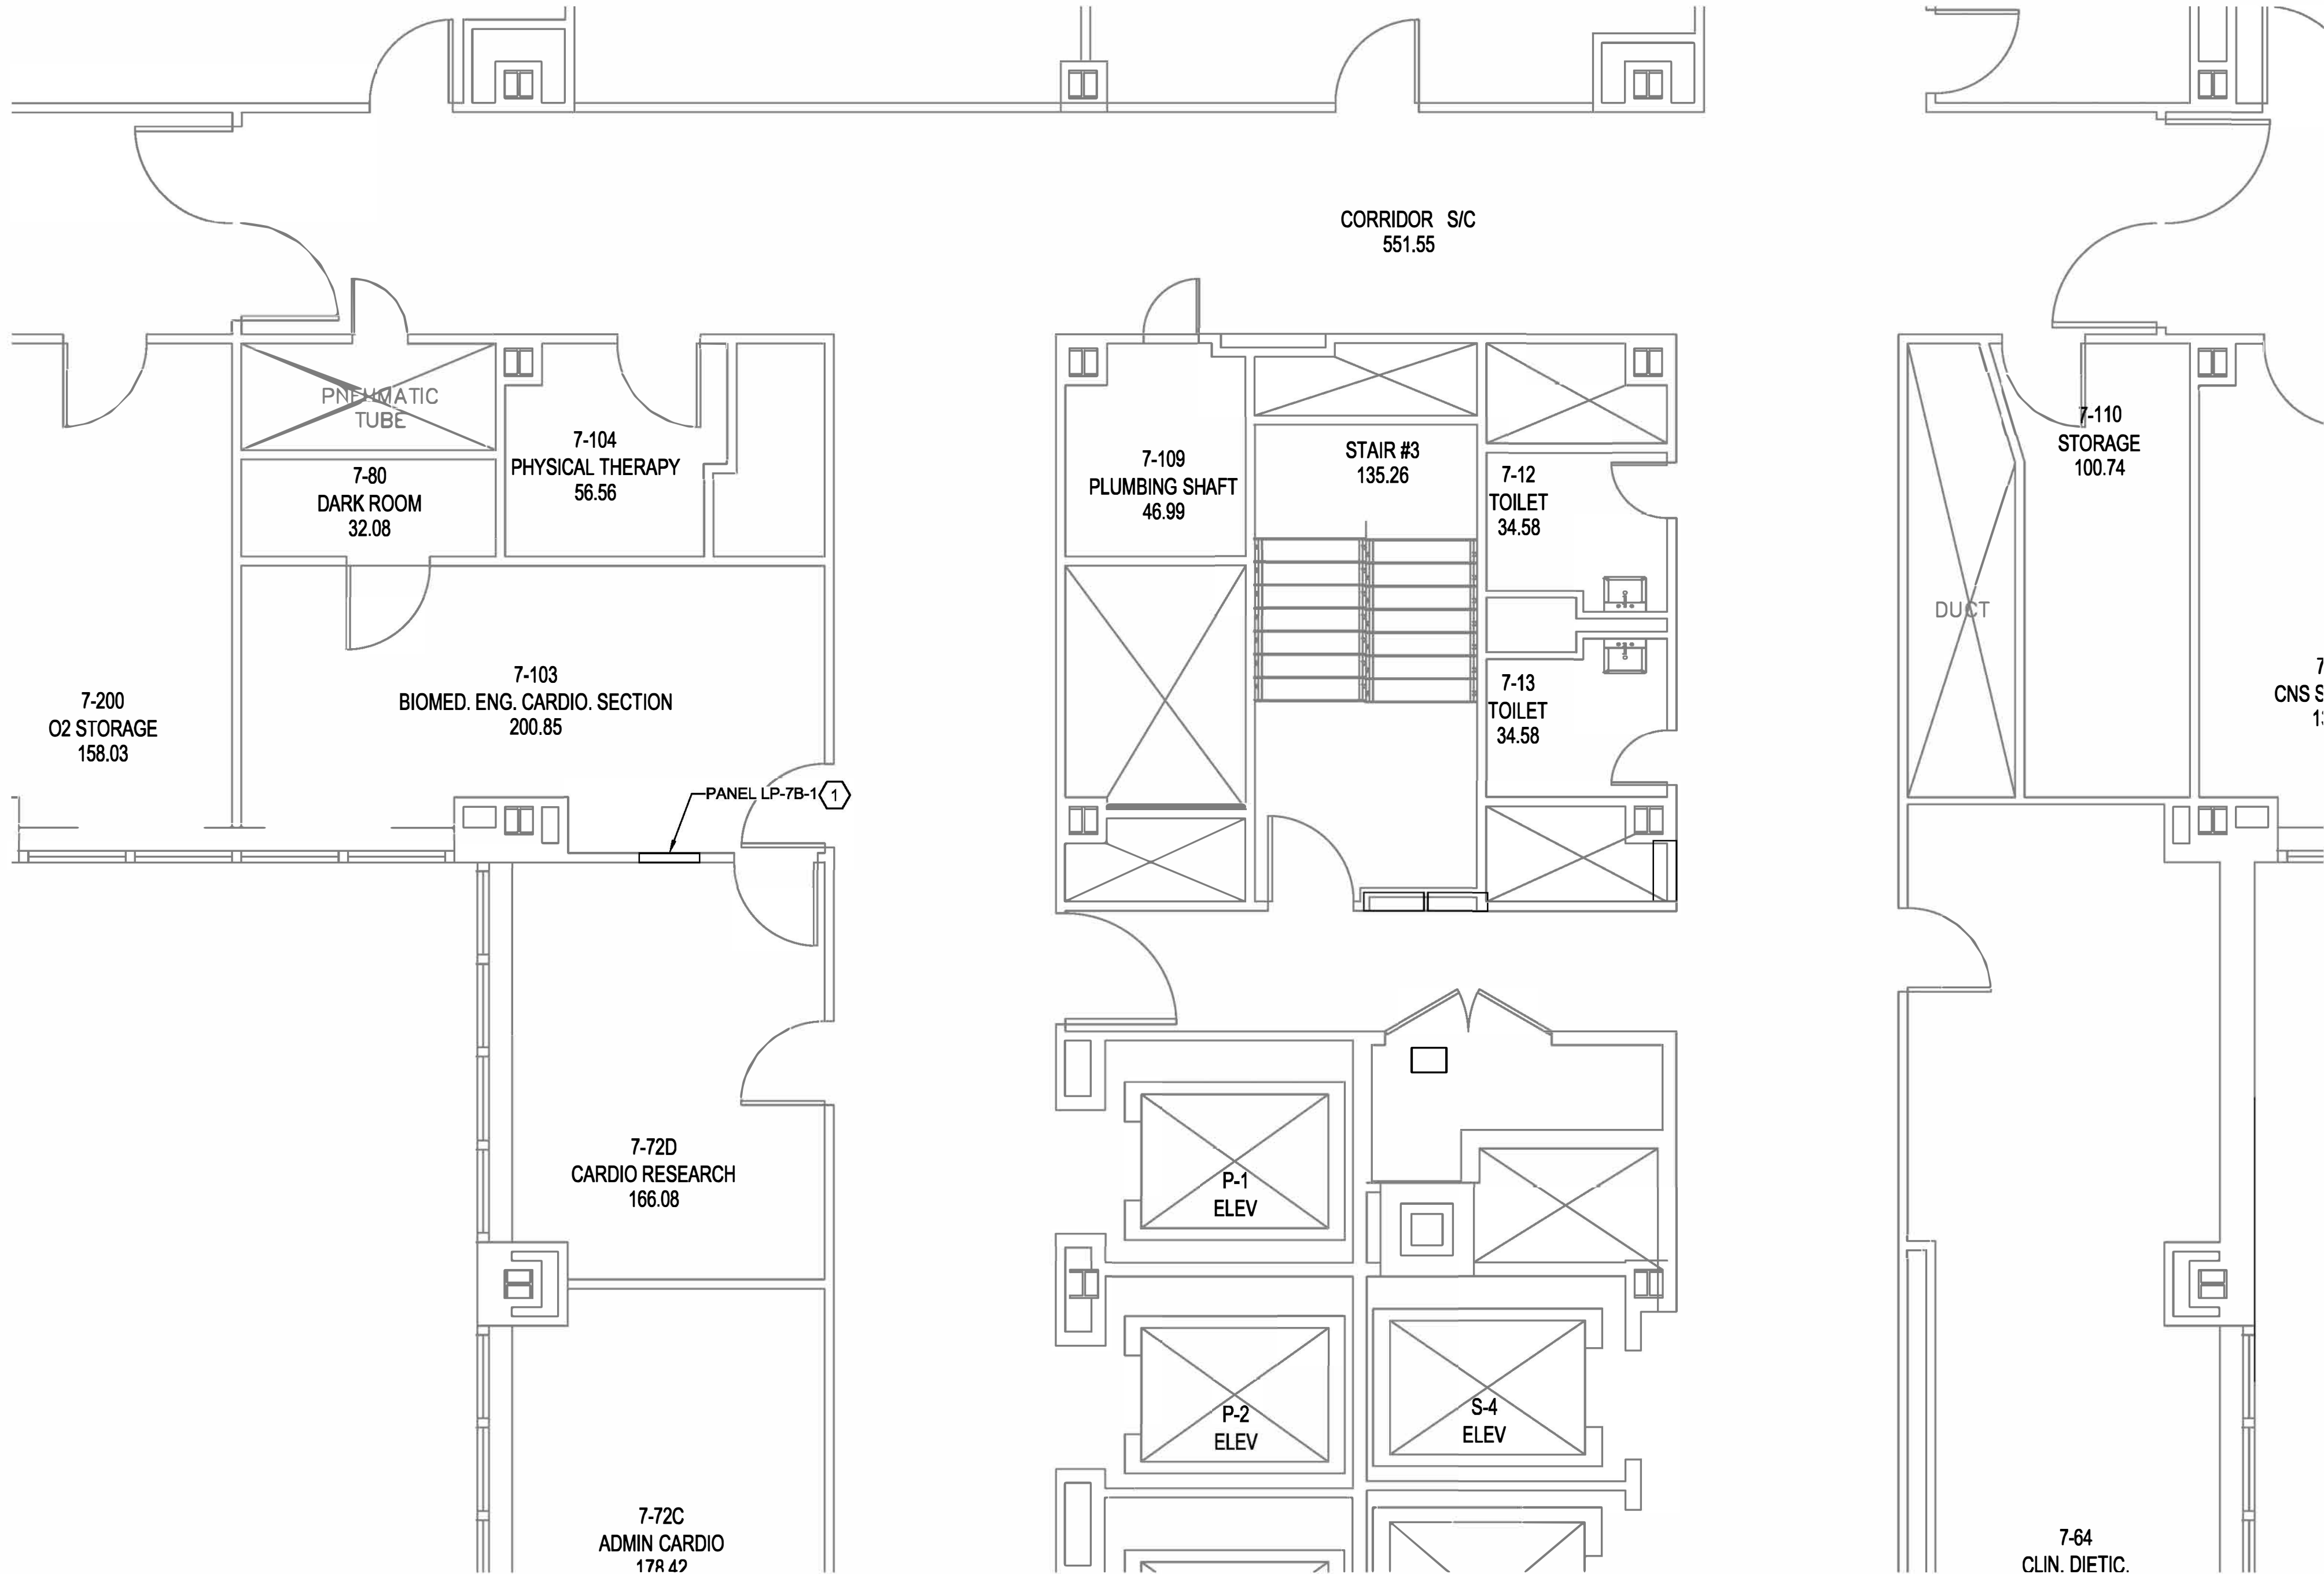

A1 PARTIAL BUILDING 1 SEVENTH FLOOR PLAN - PANEL LP-7B-1 WORK AREA
1/4"=1'-0" 4' 2' 0' 2' 4'


DRAWING KEYNOTES: (1)
1. DISCONNECT AND REMOVE AND REPLACE 2-#10, 1-#16 GND BRANCH CIRCUIT FROM PANEL INDICATED TO RECEPTACLE IN ROOM 7-103. COORDINATE EXACT LOCATION OF RECEPTACLE IN FIELD PRIOR TO CONSTRUCTION. UTILIZE EXISTING RACEWAY TO THE FURTHEST EXTENT POSSIBLE.

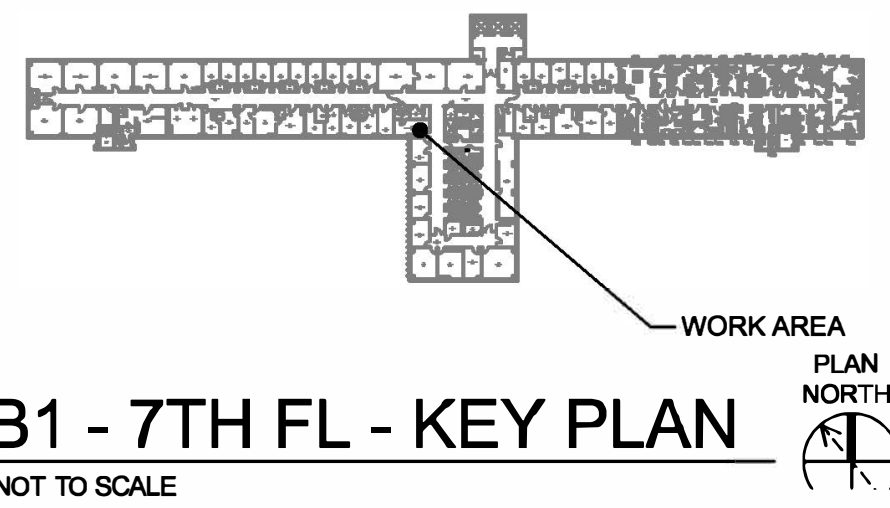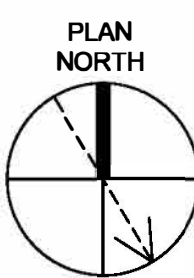

CONSULTANTS: RAMBOLL RAMBOLL AMERICAS ENGINEERING SOLUTIONS, INC. 18 LINK DRIVE BINGHAM TON NY 13902		STAMP 2022-08-17	ARCHITECT/ENGINEERS: 259 St. Ives Dr. Talent, OR 97540	APPROVED BY: VJC DATE: 08/24/22	Drawing Title TASK ORDER 16 BUILDING 1 PARTIAL 7TH FLOOR PLAN PANEL LP-7B-1 AREA Approved: Project Director	Project Title UPGRADE LIFE SAFETY/CRITICAL BRANCH ELECTRICAL DISTRIBUTION NY HARBOR HEALTHCARE CENTER VA BROOKLYN CAMPUS Location 800 POLY PLACE, BROOKLYN NY 11209 Issue Date 08/24/22 Checked BKD Drawn KMB	Project Number 630A4-16-430 Building Number 1 Drawing Number 18-01-BK EP-176 Dwg. 81 of 91	Office of Construction and Facilities Management
---	--	--------------------------------	---	--	--	--	--	---



A1 PARTIAL BUILDING 1 EIGHTH FLOOR PLAN - PANEL LP-8KA WORK AREA

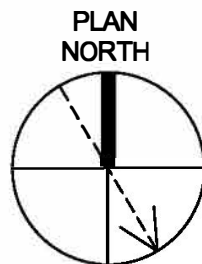

DRAWING NOTES:

1. WORK SHOWN THIS DRAWING SHALL TAKE PLACE ON NIGHT/WEEKEND SHIFTS.


DRAWING KEYNOTES: (#)

1. DISCONNECT AND REMOVE FEEDER TAP CIRCUIT, AND RECESSED ENCLOSED CIRCUIT BREAKER. REPAIR/PATCH AND PAINT WALL FROM REMOVALS. PAINT COLOR SHALL MATCH EXISTING CONDITIONS.
2. DISCONNECT AND REMOVE SURFACE MOUNTED PANEL INDICATED. DISCONNECT AND REMOVE FEEDER CIRCUIT FROM ENCLOSED CIRCUIT BREAKER COMPLETE. BRANCH CIRCUITS SHALL REMAIN FOR REUSE.
3. PROVIDE ALL MATERIAL AND LABOR TO TAP INTO EXISTING FEEDER CIRCUIT AT PANEL LP8K. PANEL LP8K IS RECESS/FLUSH MOUNTED IN WALL. PROVIDE FEEDER TAP POWER CIRCUIT AS INDICATED STARTING AT RECESSED/FLUSH PANEL. FEEDER TAP CIRCUIT LENGTH SHALL NOT EXCEED 25-FEET IN ACCORDANCE WITH NEC (240.21)(B)(2).
4. PROVIDE ENCLOSED CIRCUIT BREAKER AS INDICATED IN NEMA 12 ENCLOSURE WITH LOCKABLE COVER.
5. PROVIDE POWER CIRCUIT AS INDICATED ROUTED ABOVE SUSPENDED CEILING. COORDINATE EXACT ROUTING IN FIELD PRIOR TO CONSTRUCTION. PROVIDE ALL MATERIAL AND LABOR TO REMOVE AND REINSTALL SUSPENDED CEILING TILES/GRID AS REQUIRED TO FACILITATE POWER CIRCUIT INSTALLATION.
6. PROVIDE POWER PANEL AS INDICATED AND SCHEDULED. REFER TO POWER PANEL SCHEDULE THIS DRAWING.

REV. 0 ISSUED FOR CONSTRUCTION	08/24/22
Revisions:	Date

CONSULTANTS:

RAMBOLL
RAMBOLL AMERICAS
ENGINEERING SOLUTIONS, INC.
18 LINK DRIVE
BINGHAMTON, NY 13902

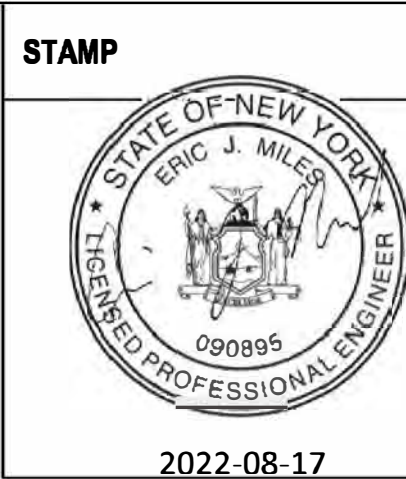

ARCHITECT/ENGINEERS:

D2X Associates
259 St. Ives Dr.
Talent, OR 97540

APPROVED BY: VJC
DATE: 08/24/22

Drawing Title
**TASK ORDER 17
BUILDING 1 PARTIAL 8TH FL
PANEL LP-8KA AREA**

Approved: Project Director

Project Title
**UPGRADE LIFE SAFETY/CRITICAL BRANCH
ELECTRICAL DISTRIBUTION
NY HARBOR HEALTHCARE CENTER
VA BROOKLYN CAMPUS**

Location 800 POLY PLACE, BROOKLYN NY 11209

 
Issue Date
08/24/22

Checked
BKD

Drawn
KMB

Project Number
630A4-16-430
Building Number
1
Drawing Number
18-01-BK
EP-177
Dwg. 82 of 91

Office of
Construction
and Facilities
Management






1. WORK SHOWN THIS DRAWING SHALL TAKE PLACE ON NIGHT/WEEKEND SHIFTS

1. DISCONNECT AND REMOVE (2) 30A, SINGLE POLE, 120V CIRCUIT BREAKERS IN POLE POSITIONS 21 AND 23. PROVIDE (2) 20A SINGLE POLE, 120V CIRCUIT BREAKERS FOR POLE POSITIONS 21 AND 23. CIRCUIT BREAKER SHALL MATCH EXISTING MANUFACTURER AND INTERRUPTING RATING. PANEL LP-14C IS A GE A-SERIES PANEL




one eighth inch = one foot

three inches = one foot
one and one half inches = one foot
one inch = one foot
three quarters inch = one foot
one half inch = one foot
three eighths inch = one foot
one quarter inch = one foot
one eighth inch = one foot

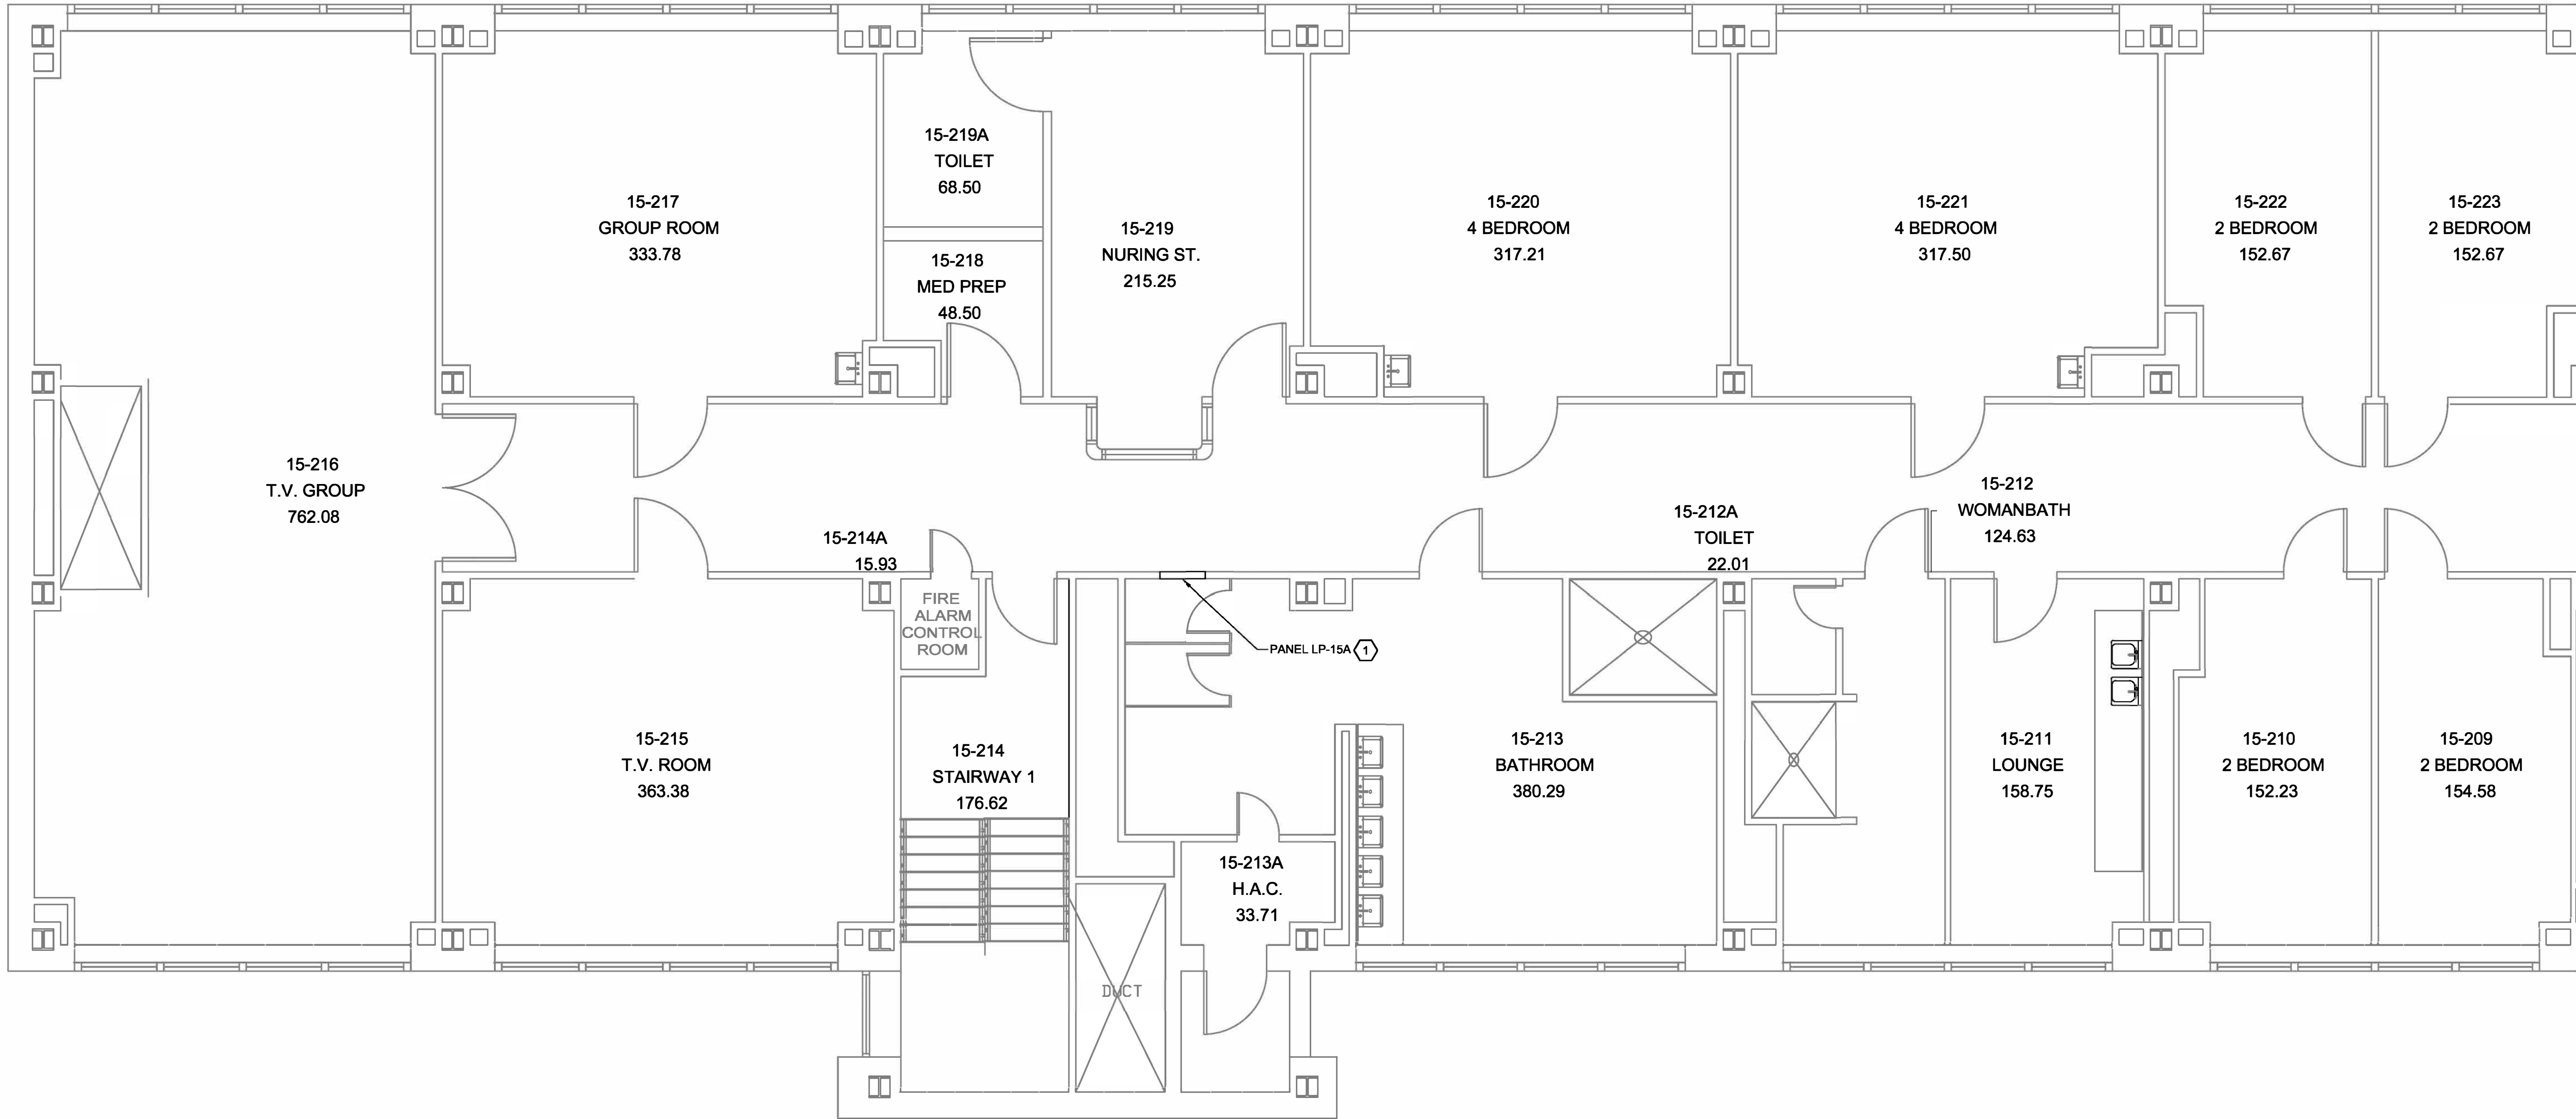


A1 PARTIAL BUILDING 1 FIFTEENTH FLOOR PLAN - PANEL LP-15A WORK AREA
1/4"=1'-0" 4' 2' 0 2' 4'

- DRAWING KEYNOTES:**
1. PROVIDE ALL MATERIAL AND LABOR TO INSTALL VERTICAL CABLE SUPPORT BUSHING ON FEEDER CIRCUIT TO PANEL LP-15A. PANEL LP-15A IS RECESSED/FLUSH MOUNTED IN TILE WALL.

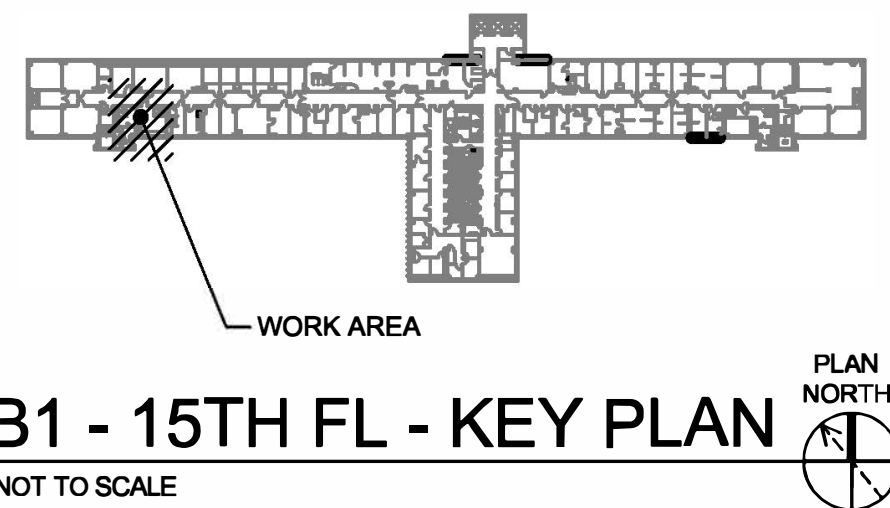

CONSULTANTS: RAMBOLL RAMBOLL AMERICAS ENGINEERING SOLUTIONS, INC. 18 LINK DRIVE BINGHAMTON, NY 13902		STAMP 	ARCHITECT/ENGINEERS: 259 St. Ives Dr. Talent, OR 97540	APPROVED BY: VJC DATE: 08/24/22	Drawing Title TASK ORDER 19 BUILDING 1 PARTIAL FIFTEENTH FLOOR PLAN PANEL LP15A Approved: Project Director	Project Title UPGRADE LIFE SAFETY/CRITICAL BRANCH ELECTRICAL DISTRIBUTION NY HARBOR HEALTHCARE CENTER VA BROOKLYN CAMPUS Location 800 POLY PLACE, BROOKLYN NY 11209 Issue Date 08/24/22 Checked BKD Drawn KMB	Project Number 630A4-16-430 Building Number 1 Drawing Number 18-01-BK EP-179 Dwg. 84 of 91	Office of Construction and Facilities Management
---	--	------------------	---	--	---	--	--	---


three inches = one foot
one and one half inches = one foot
one inch = one foot
three quarters inch = one foot
one half inch = one foot
three eighths inch = one foot
one quarter inch = one foot
one eighth inch = one foot

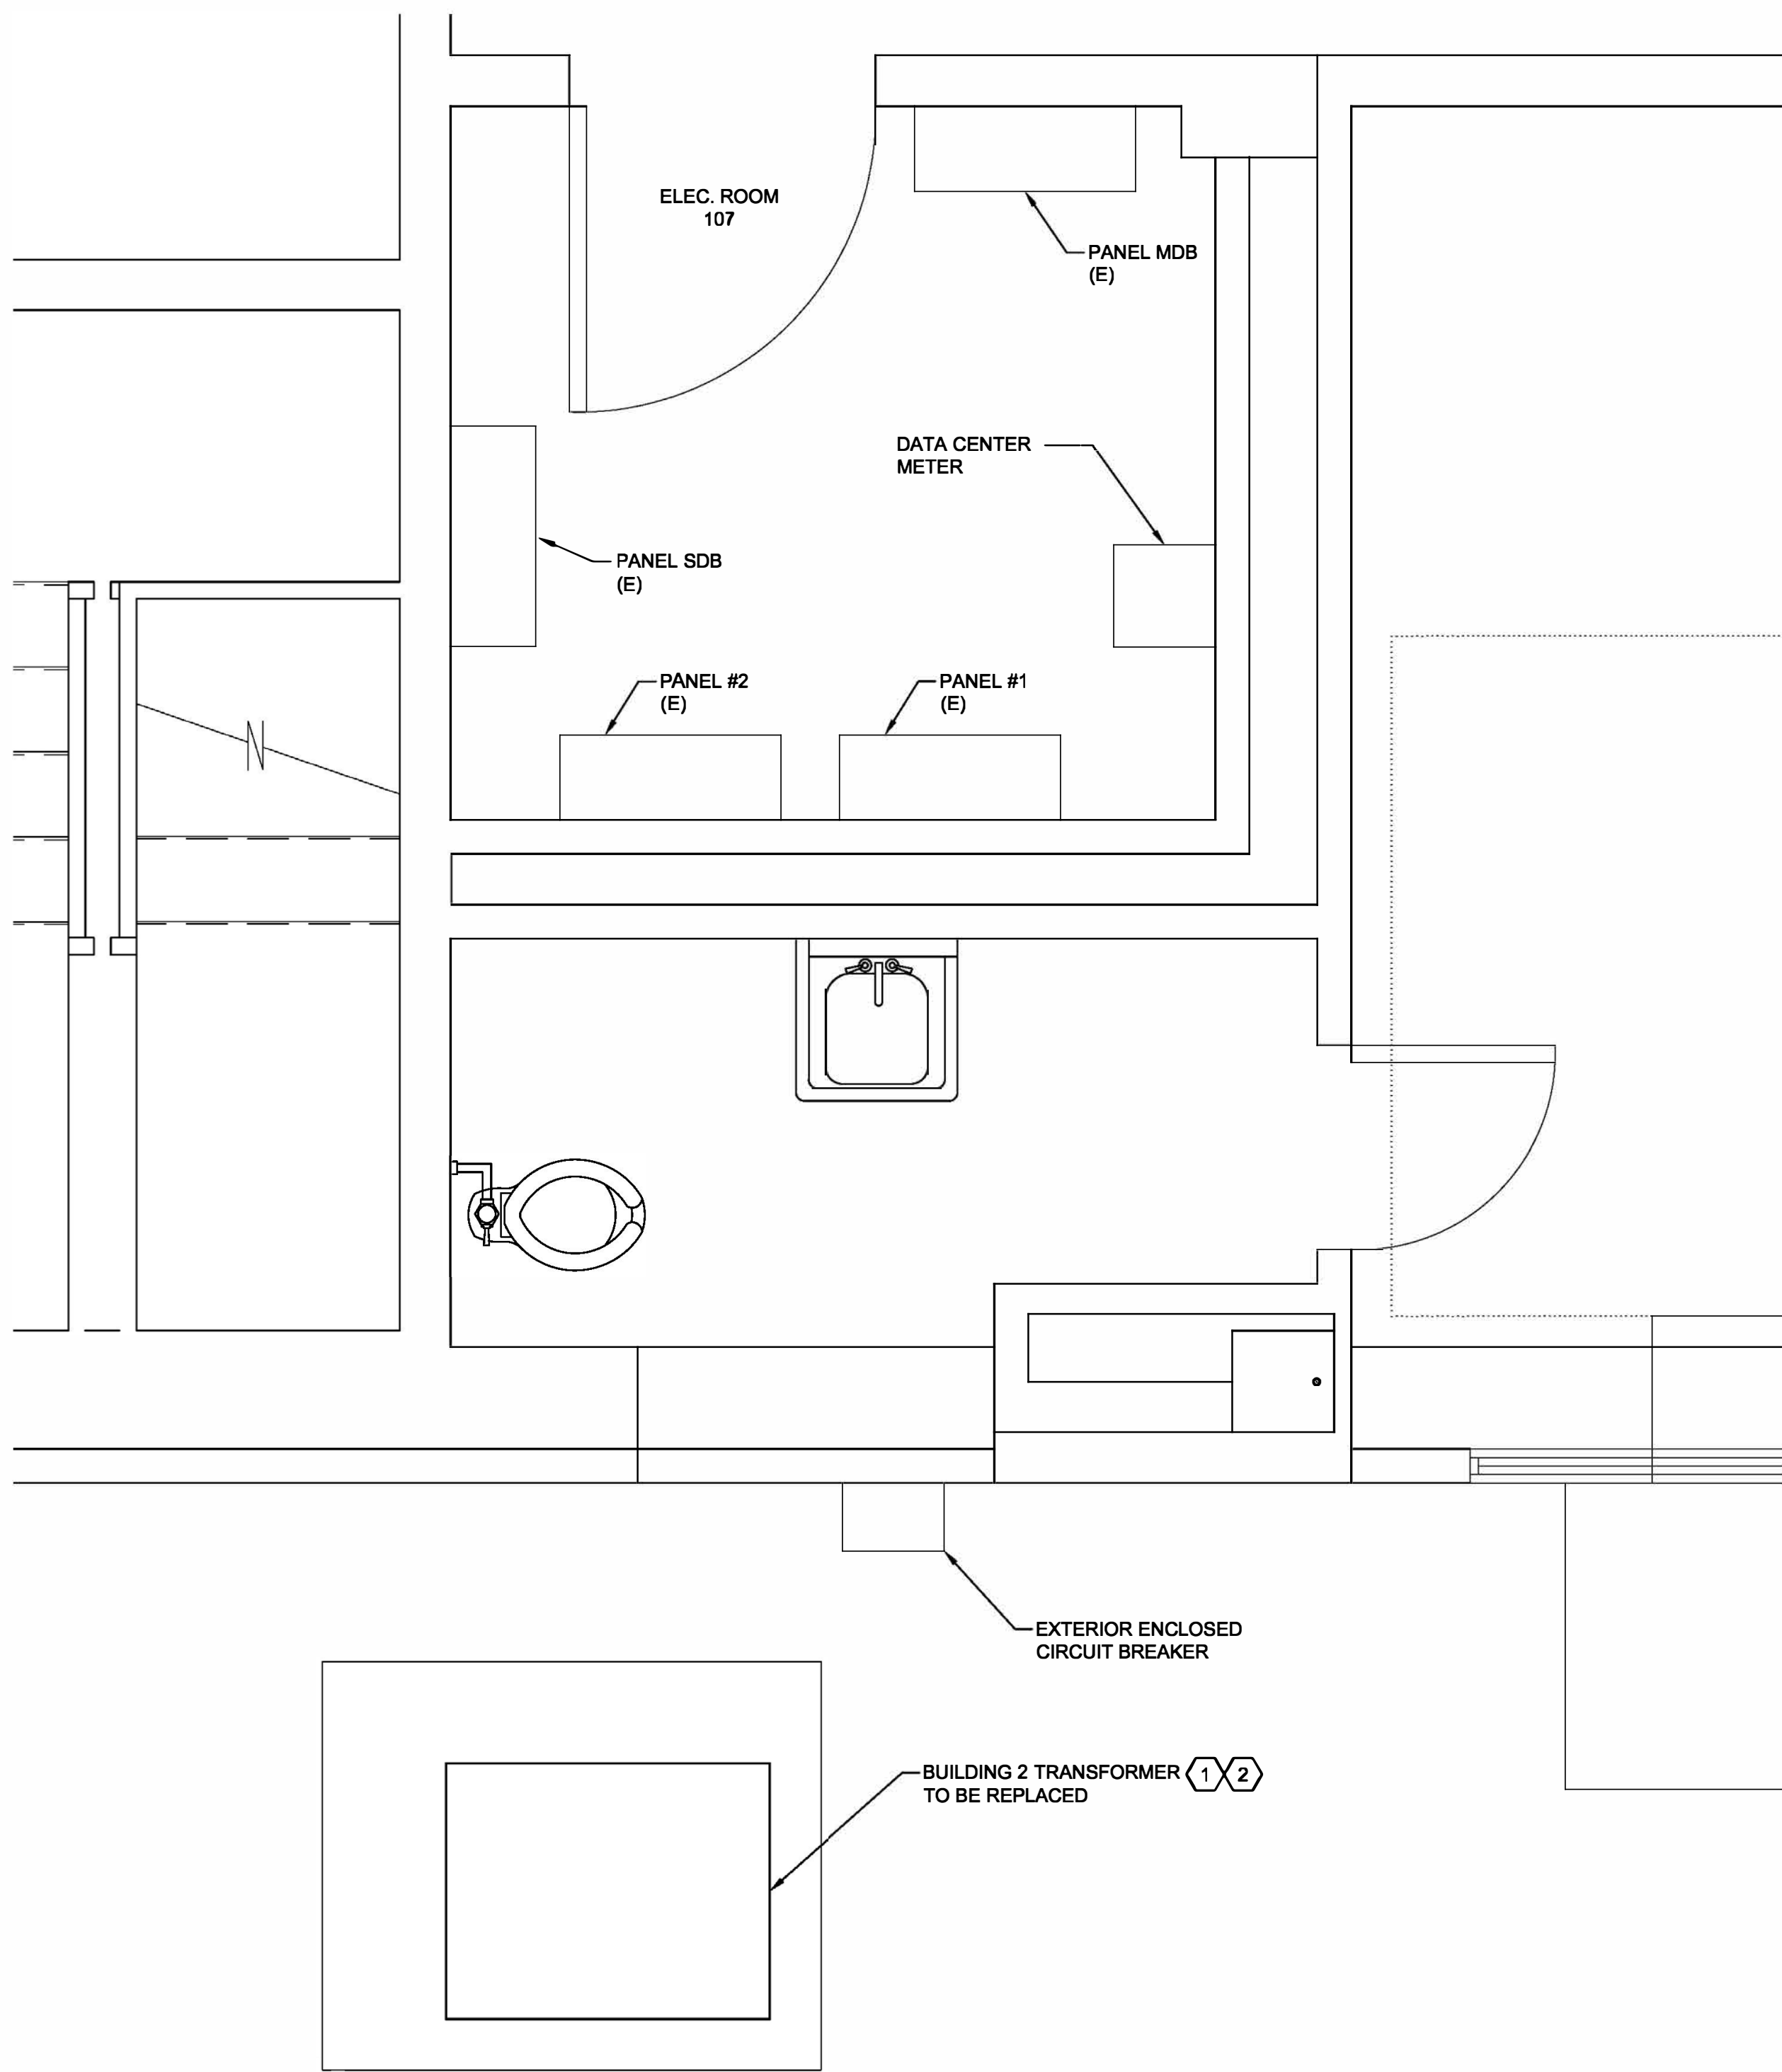

A1 PARTIAL BUILDING 2 FIRST FLOOR PLAN
3/4"=1'-0" 6" 3" 0 1' 2'
PLAN NORTH


DRAWING NOTES:
1. WORK SHOWN THIS DRAWING SHALL TAKE PLACE ON NIGHT/WEEKEND SHIFTS.

DRAWING KEYNOTES:
1. DISCONNECT AND REMOVE TRANSFORMER INDICATED. CONCRETE EQUIPMENT PAD AND GROUNDING SHALL REMAIN FOR REUSE.
2. DISCONNECT, REMOVE, AND REPLACE POWER CIRCUIT CONDUCTORS INDICATED. CONDUIT SHALL REMAIN AND BE REUSED.
3. PROVIDE TRANSFORMER AS INDICATED, SCHEDULED AND SPECIFIED. SECURELY FASTEN TO EXISTING CONCRETE EQUIPMENT PAD. PROVIDE ALL MATERIAL AND LABOR TO TERMINATE TO EXISTING PRIMARY AND SECONDARY CONDUCTORS INCLUDING ANY REQUIRED CABLE EXTENSIONS. PROVIDE ALL MATERIAL AND LABOR TO TIE INTO EXISTING GROUNDING ELECTRODE SYSTEM INCLUDING ANY REQUIRED CABLE EXTENSIONS.

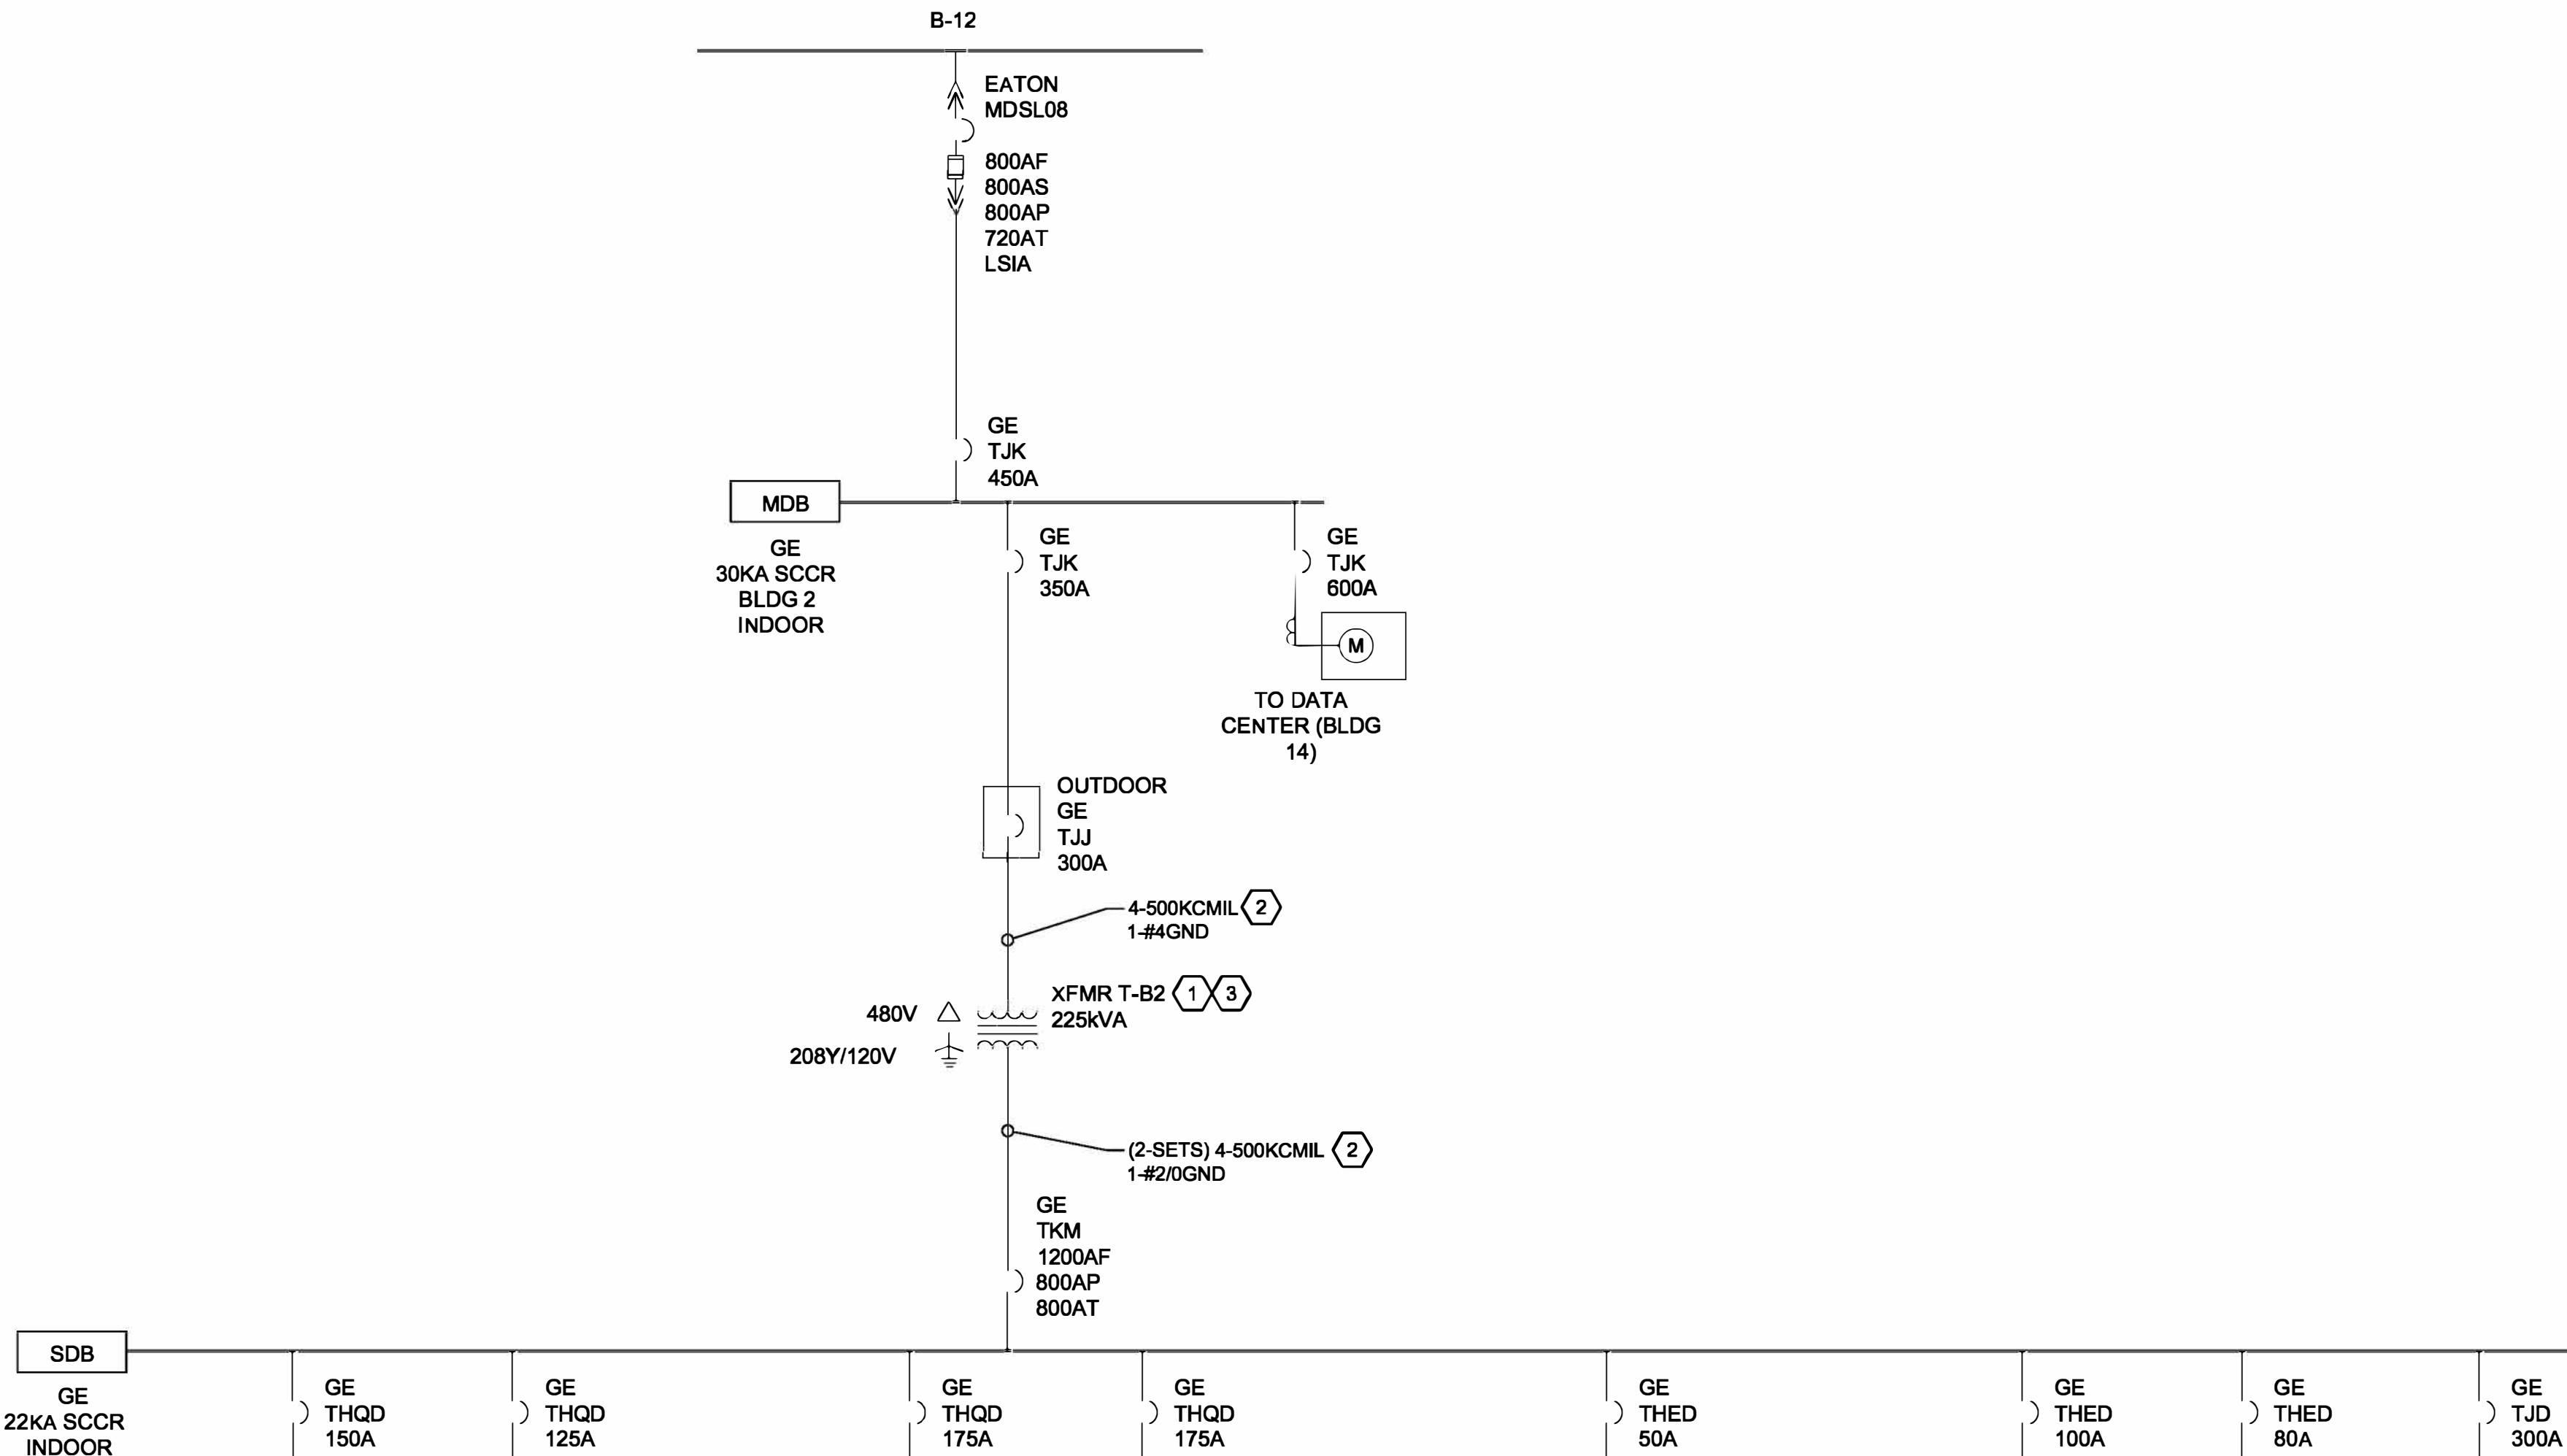

A6 PARTIAL BUILDING 2 ONE-LINE DIAGRAM
NOT TO SCALE


TRANSFORMER SCHEDULE							
NO.	SERVICE	kVA	VOLTAGE		CONNECTION		REMARKS
			PRIM.	SECOND.	PRIM.	SECOND.	
T-B2	BUILDING 2	225	480V	208/120V	Δ	Y	DRY-TYPE NEMA 3R

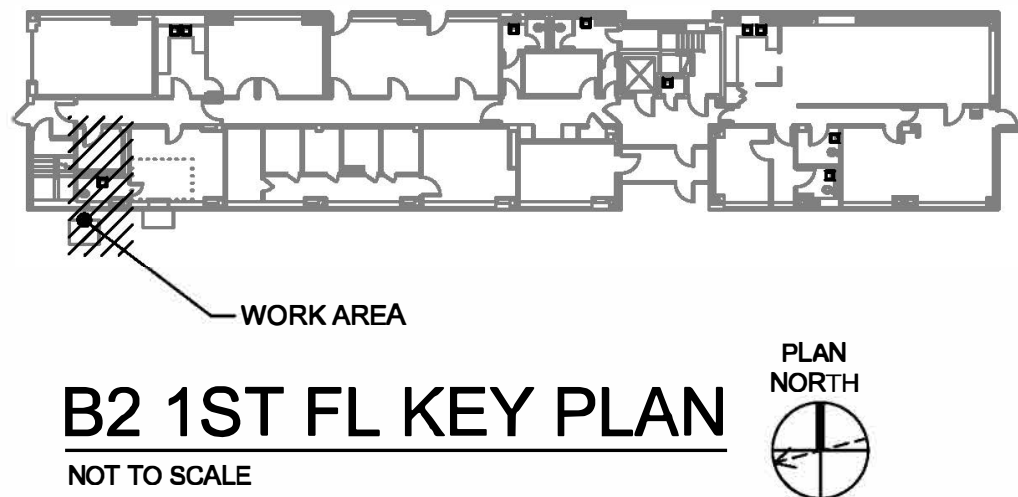


B2 1ST FL KEY PLAN
NOT TO SCALE
PLAN NORTH

CONSULTANTS: RAMBOLL RAMBOLL AMERICAS ENGINEERING SOLUTIONS, INC. 18 LINK DRIVE BINGHAMTON, NY 13902		STAMP 	ARCHITECT/ENGINEERS: 259 St. Ives Dr. Talent, OR 97540	APPROVED BY: VJC DATE: 08/24/22	Drawing Title TASK ORDER 20 BUILDING 2 PARTIAL FIRST FLOOR PLAN AND ONE-LINE DIAGRAM Approved: Project Director	Project Title UPGRADE LIFE SAFETY/CRITICAL BRANCH ELECTRICAL DISTRIBUTION NY HARBOR HEALTHCARE CENTER VA BROOKLYN CAMPUS Location 800 POLY PLACE, BROOKLYN NY 11209 Issue Date 08/24/22 Checked BKD Drawn KMB	Project Number 630A4-16-430 Building Number 2 Drawing Number 18-01-BK EP-180 Dwg. 85 of 91	Office of Construction and Facilities Management
---	--	------------------	---	--	--	--	---	---

three inches = one foot
one and one half inches = one foot
one inch = one foot
three quarters inch = one foot
one half inch = one foot
three eighths inch = one foot
one quarter inch = one foot
one eighth inch = one foot

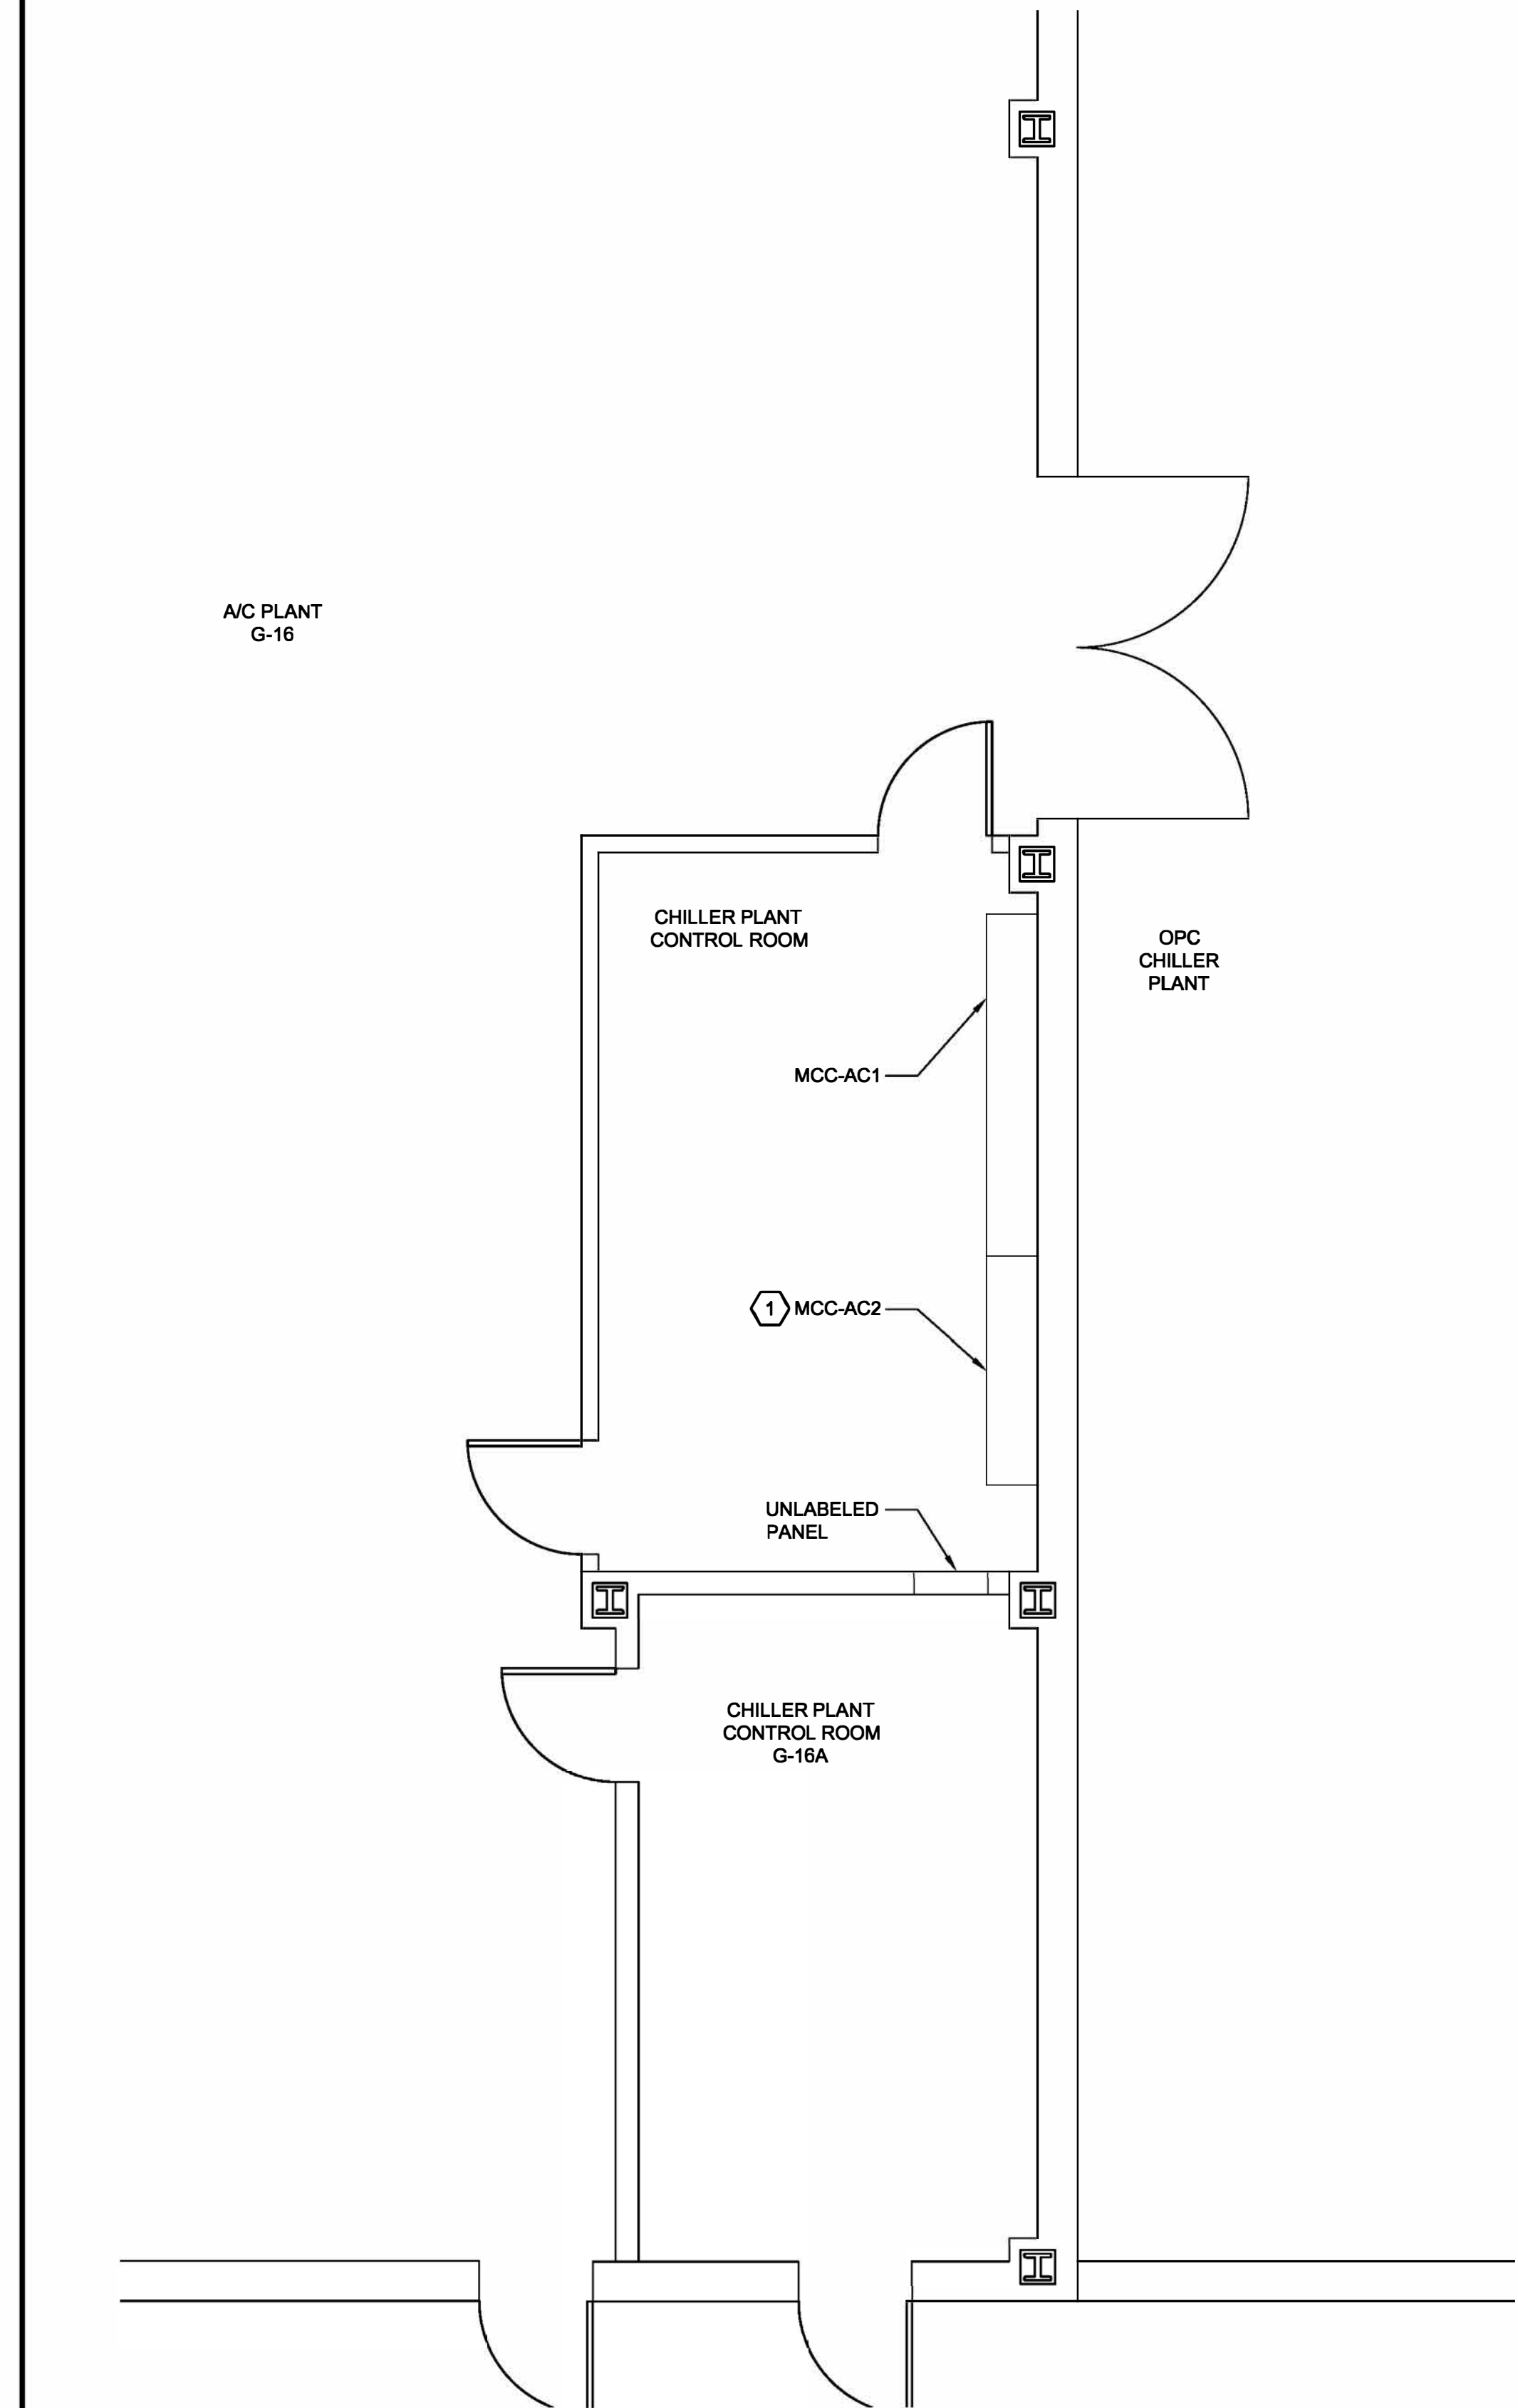

A1 PARTIAL BUILDING 4 FIRST FLOOR PLAN - MCC-AC2 AREA

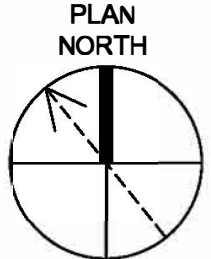


DRAWING NOTES:

1. WORK SHOWN THIS DRAWING SHALL BE COORDINATED WITH THE VA TO TAKE PLACE DURING THE HEATING SEASON ON A NIGHT/WEEKEND SHIFT.

INSTALLATION KEYNOTES:


1. DE-ENERGIZE MOTOR CONTROL CENTER MCC-AC2 AT MAIN SWITCHGEAR UNIT SWGR-A IN BUILDING 1. PERFORM THOROUGH CLEANING OF ALL SECTIONS TO REMOVE ALL DEBRIS FROM INSIDE EACH MCC SECTION ENCLOSURE AND INTERIOR BREAKERS/BUS.

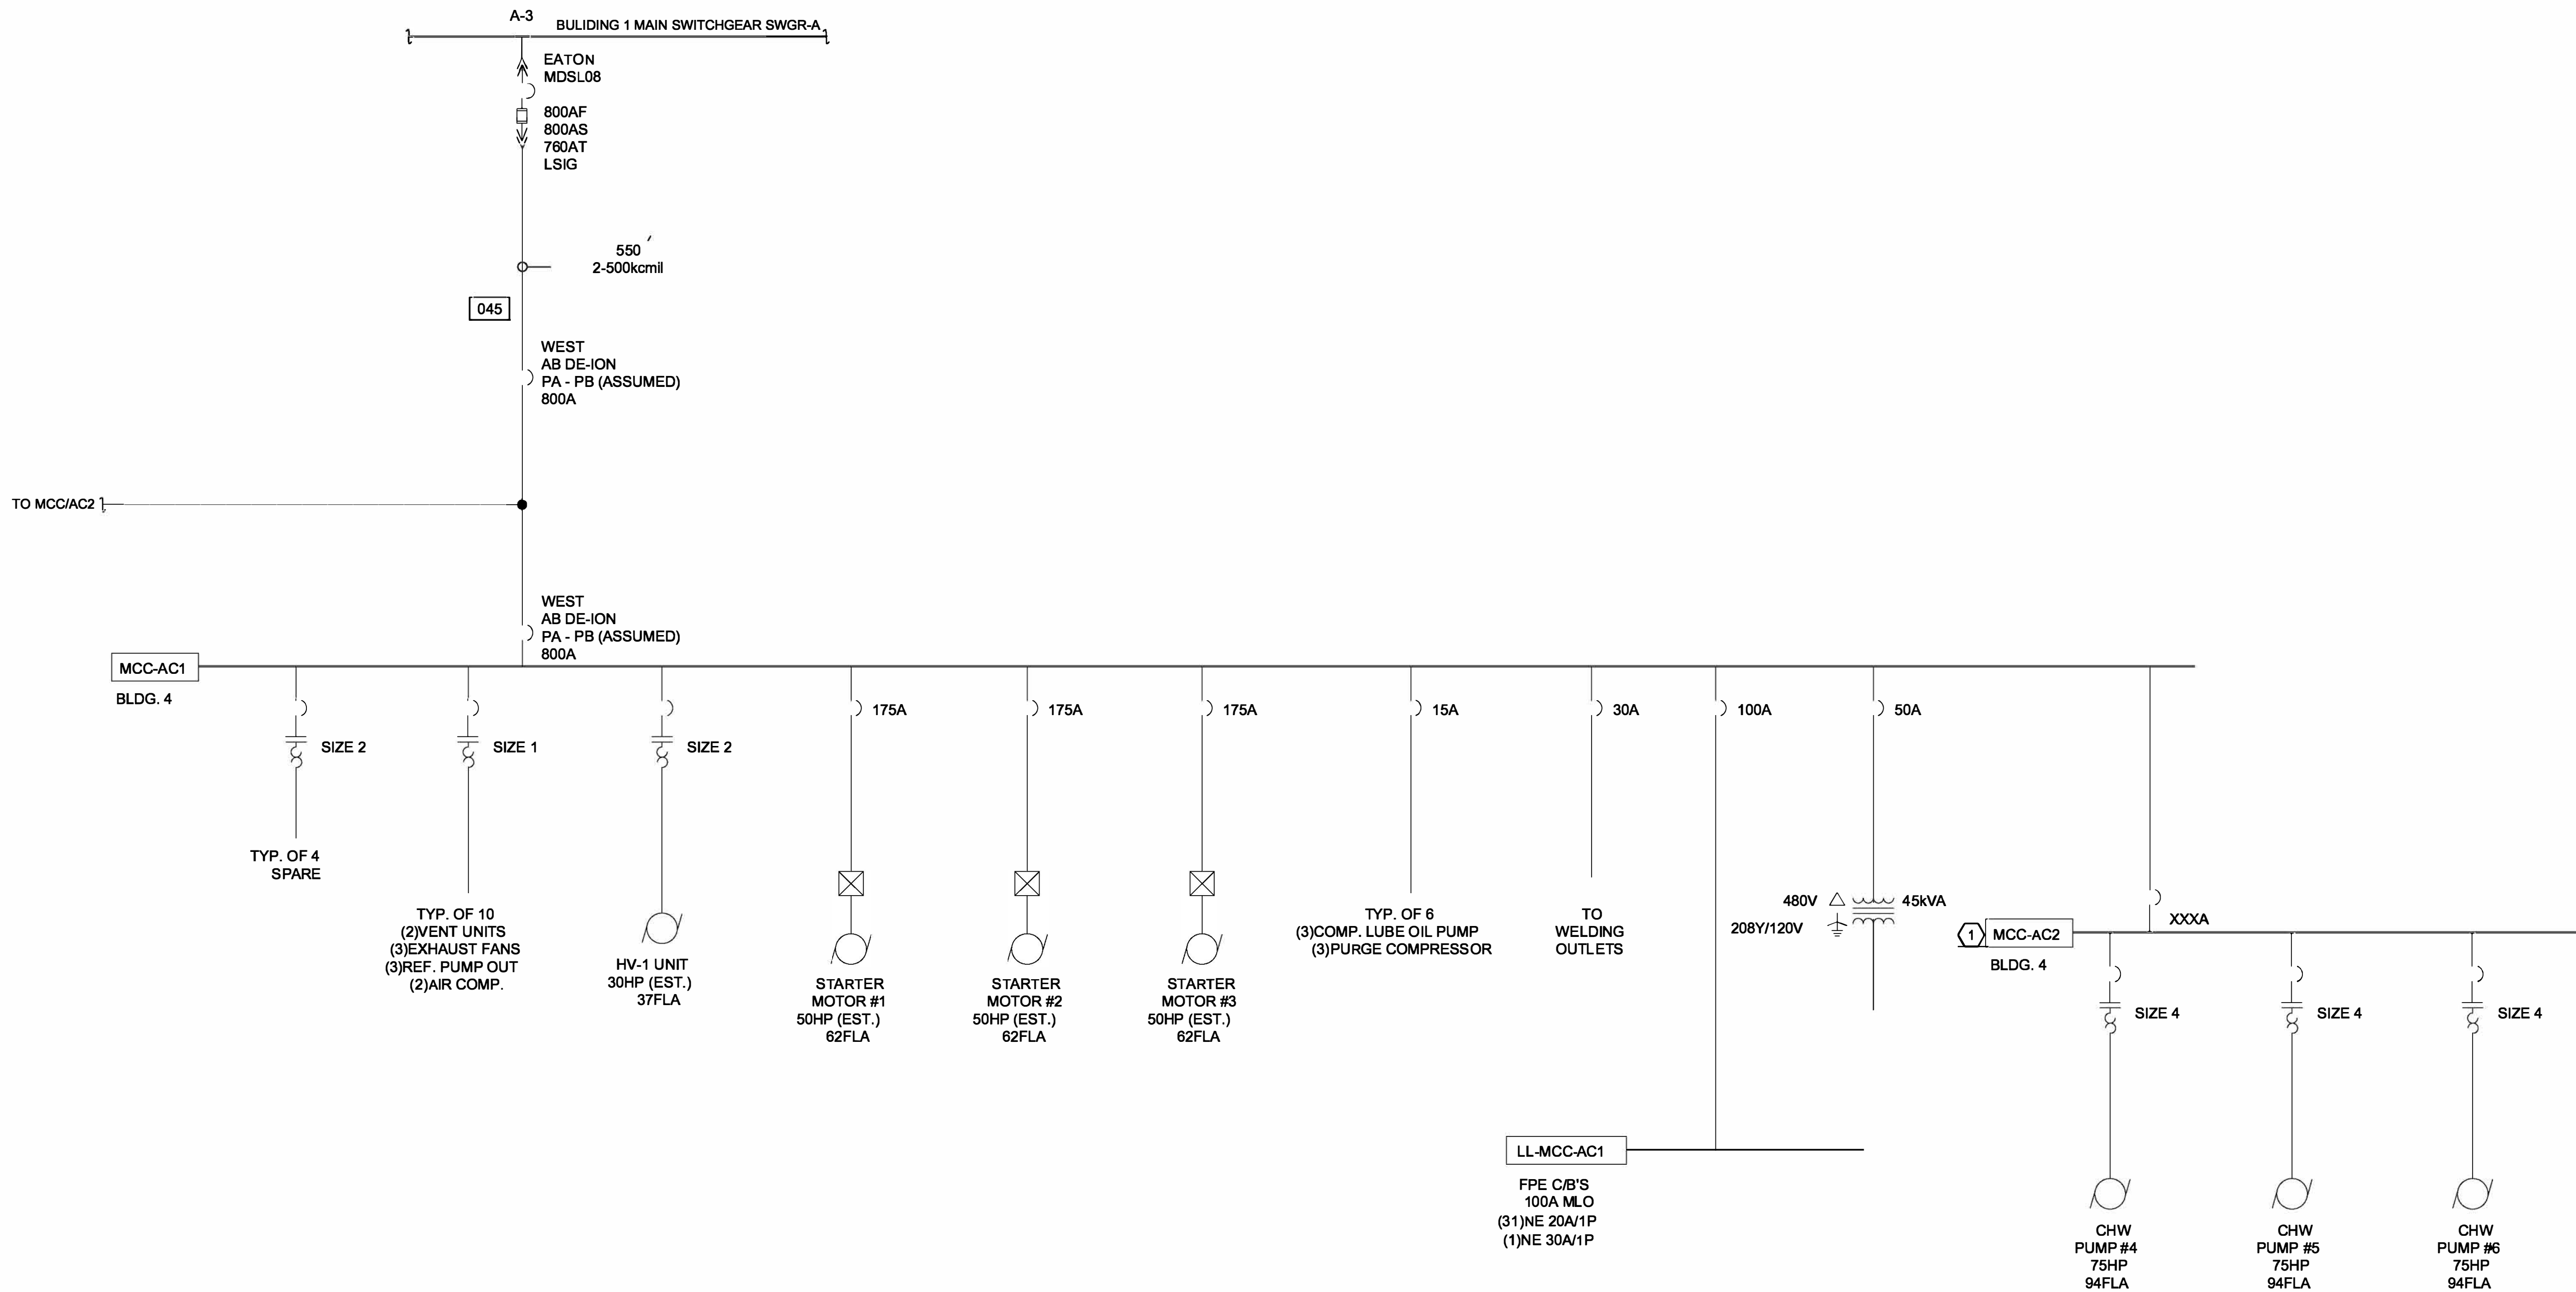

A3 PARTIAL BUILDING 4 ONE-LINE DIAGRAM

DIAGRAM NOTES:

1. ONE-LINE DIAGRAM OF MCC-AC2 SHOWN FOR REFERENCE ONLY.

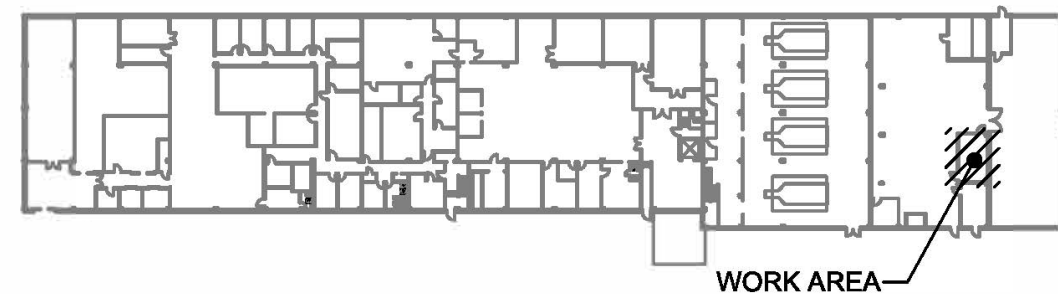


B14 - KEY PLAN



CONSULTANTS: RAMBOLL RAMBOLL AMERICAS ENGINEERING SOLUTIONS, INC. 18 LINK DRIVE BINGHAMTON, NY 13902		STAMP 2022-08-17	ARCHITECT/ENGINEERS: 259 St. Ives Dr. Talent, OR 97540	APPROVED BY: VJC DATE: 08/24/22	Drawing Title TASK ORDER 21 PARTIAL BUILDING 4 PLAN AND ONE-LINE DIAGRAM Approved: Project Director	Project Title UPGRADE LIFE SAFETY/CRITICAL BRANCH ELECTRICAL DISTRIBUTION NY HARBOR HEALTHCARE CENTER VA BROOKLYN CAMPUS Location 800 POLY PLACE, BROOKLYN NY 11209 Issue Date 08/24/22 Checked BKD Drawn KMB	Project Number 630A4-16-430 Building Number 4 Drawing Number 18-01-BK EP-181 Dwg. 86 of 91	Office of Construction and Facilities Management
---	--	--------------------------------	---	--	---	--	---	---

three inches = one foot
one and one half inches = one foot
one inch = one foot
three quarters inch = one foot
one half inch = one foot
three eighths inch = one foot
one quarter inch = one foot
one eighth inch = one foot


A
B
C
D
E
F

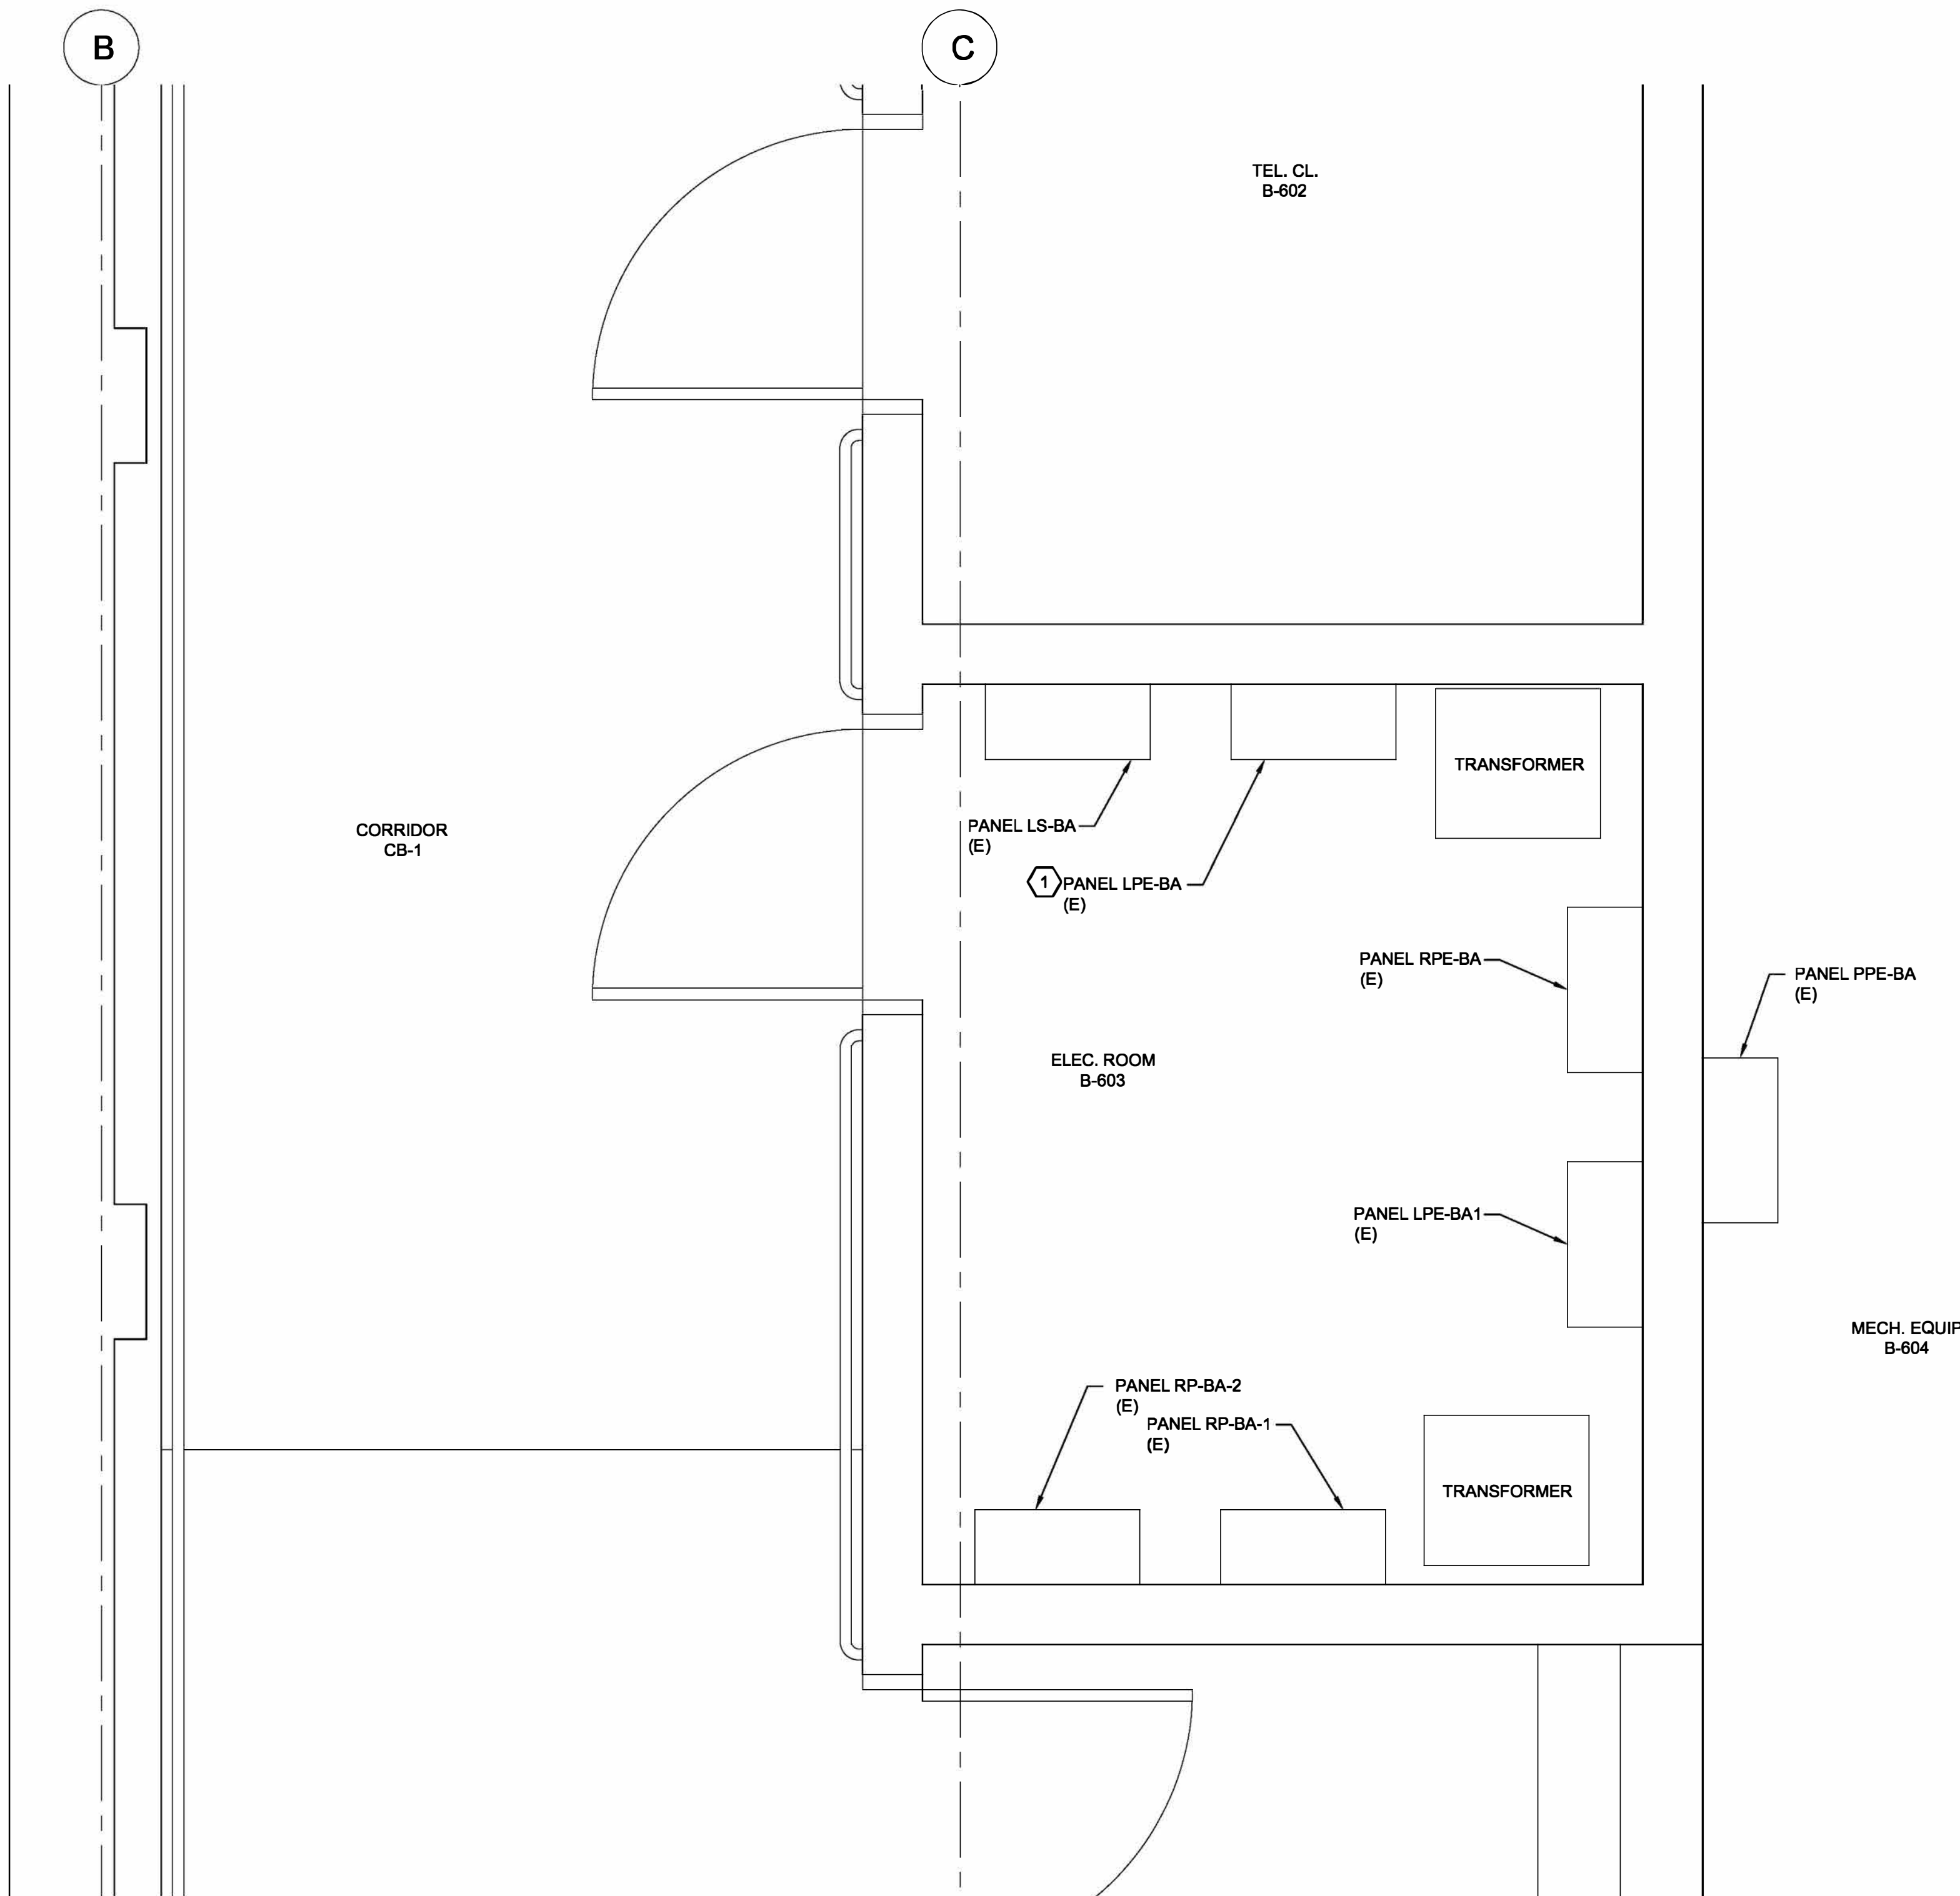

A1 PARTIAL BLDG 15 BASEMENT FLOOR ELECTRICAL PLAN
3/4"=1'-0" 6" 3" 0 1' 2'
PLAN NORTH

DRAWING NOTES:
1. WORK SHOWN THIS DRAWING SHALL TAKE PLACE ON NIGHT/WEEKEND SHIFTS.

INSTALLATION KEYNOTES: (#)
1. DE-ENERGIZE PANEL LPE-BA AT PANEL HDP-1CA IN MAIN SWITCHGEAR ROOM ON THE GROUND FLOOR. PERFORM THOROUGH CLEANING TO REMOVE ALL DEBRIS FROM INSIDE PANEL ENCLOSURE AND INTERIOR BREAKERS/BUS.

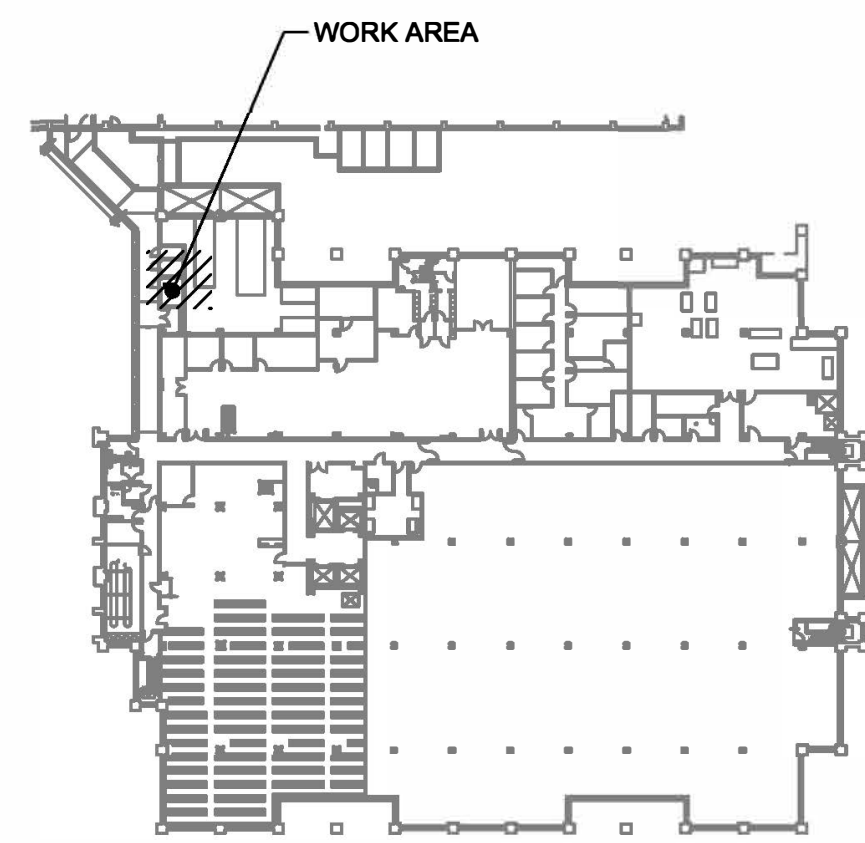


B15 GROUND FL - KEY PLAN
NOT TO SCALE
PLAN NORTH

		CONSULTANTS:		STAMP		ARCHITECT/ENGINEERS:		APPROVED BY: VJC		DATE: 08/24/22		Drawing Title TASK ORDER 23 BUILDING 15 PARTIAL BASEMENT PLAN PANEL LPE-BA			Project Title UPGRADE LIFE SAFETY/CRITICAL BRANCH ELECTRICAL DISTRIBUTION NY HARBOR HEALTHCARE CENTER VA BROOKLYN CAMPUS			Project Number 630A4-16-430		Office of Construction and Facilities Management	
		RAMBOLL RAMBOLL AMERICAS ENGINEERING SOLUTIONS, INC. 18 LINK DRIVE BINGHAM TQ, NY 1 3902		STATE OF NEW YORK ERIC J. MILES 090916 REGISTERED PROFESSIONAL ENGINEER 2022-08-17		D2X Associates 259 St. Ives Dr. Talent, OR 97540		Approved: Project Director		Location 800 POLY PLACE, BROOKLYN NY 11209			Building Number 15		Drawing Number 18-01-BK EP-182		Dwg. 87 of 91				
													Issue Date 08/24/22		Checked BKD				Drawn KMB		
REV. 0 ISSUED FOR CONSTRUCTION																					
Revisions:		Date																			

three inches = one foot
one and one half inches = one foot
one inch = one foot
three quarters inch = one foot
one half inch = one foot
one quarter inch = one foot
one eighth inch = one foot


File Path: \\D:\ASCC\2022\08\18\UPGRADE ELECTRICAL DISTRIBUTION\B18-01-BK-EP-184.DWG PLOT DATE: 8/18/2022 8:17 PM

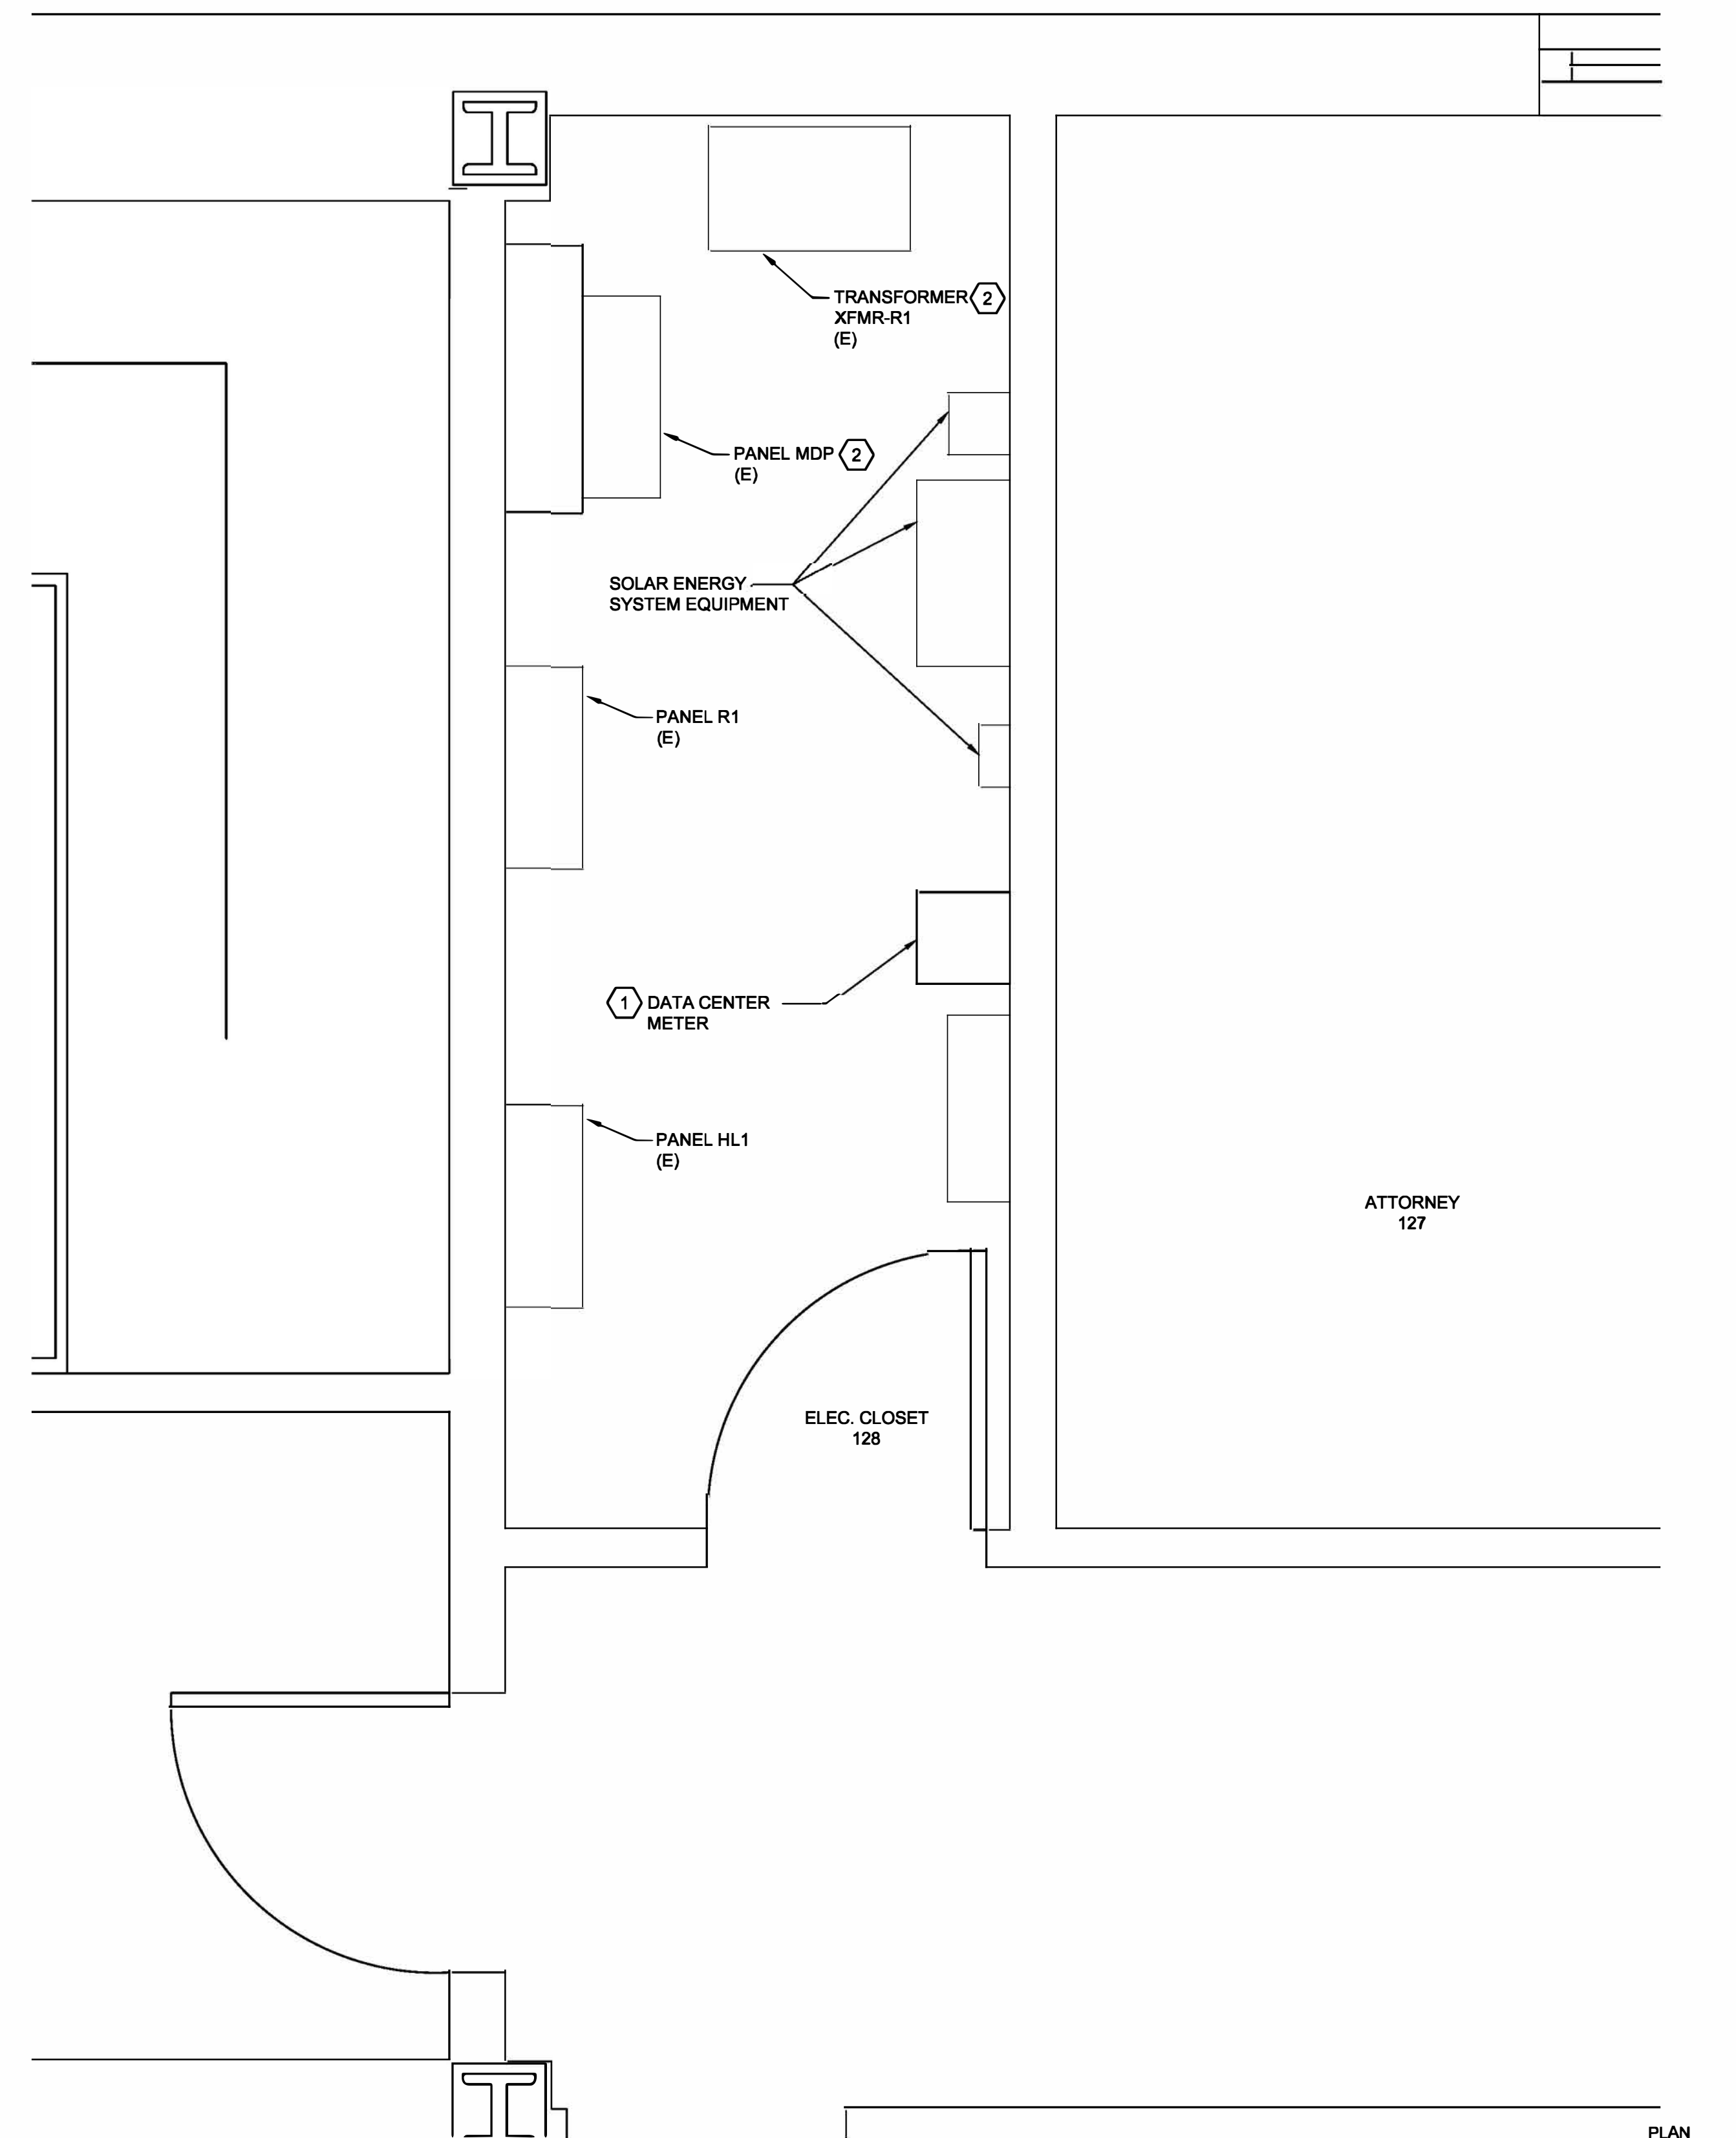


A1 PA RTIAL BUILDING 14 FIRST FLOOR PLAN -DATA CENTER METERING
3/4"=1'-0"

DRAWING NOTES:
1. WORK SHOWN THIS DRAWING SHALL TAKE PLACE ON NIGHT/WEEKEND SHIFTS.

INSTALLATION KEYNOTES: (#)
1. PROVIDE METER FOR DATACENTER FEEDER FROM PANEL MDP. METER SHALL BE SQUARE D POWER LOGIC PM800 OR APPROVED EQUAL WITH ETHERNET COMMUNICATION CARD. PROVIDE REVENUE METERING GRADE 575 ON FEEDER CIRCUIT WITHIN PANEL MDP AND ASSOCIATED CABLE TO METER IN 3/4" C. PROVIDE CATSE CABLE IN 3/4" C TO DATA CONNECTION POINT. METER SHALL BE CONNECTED TO VA NATIONAL METERING SYSTEM.
2. DISCONNECT, REMOVE AND REPLACE POWER CIRCUIT CONDUCTORS COMPLETE FROM PANEL MDP TO PANEL R1 TRANSFORMER PRIMARY CONNECTION. PROVIDE ALL REQUIRED TERMINATION HARDWARE. CONDUIT SHALL REMAIN FOR REUSE. PROVIDE ALL MATERIAL AND LABOR TO REPLACE LUGS IN SOURCE CIRCUIT BREAKER AS REQUIRED FOR CONDUCTOR TERMINATIONS.

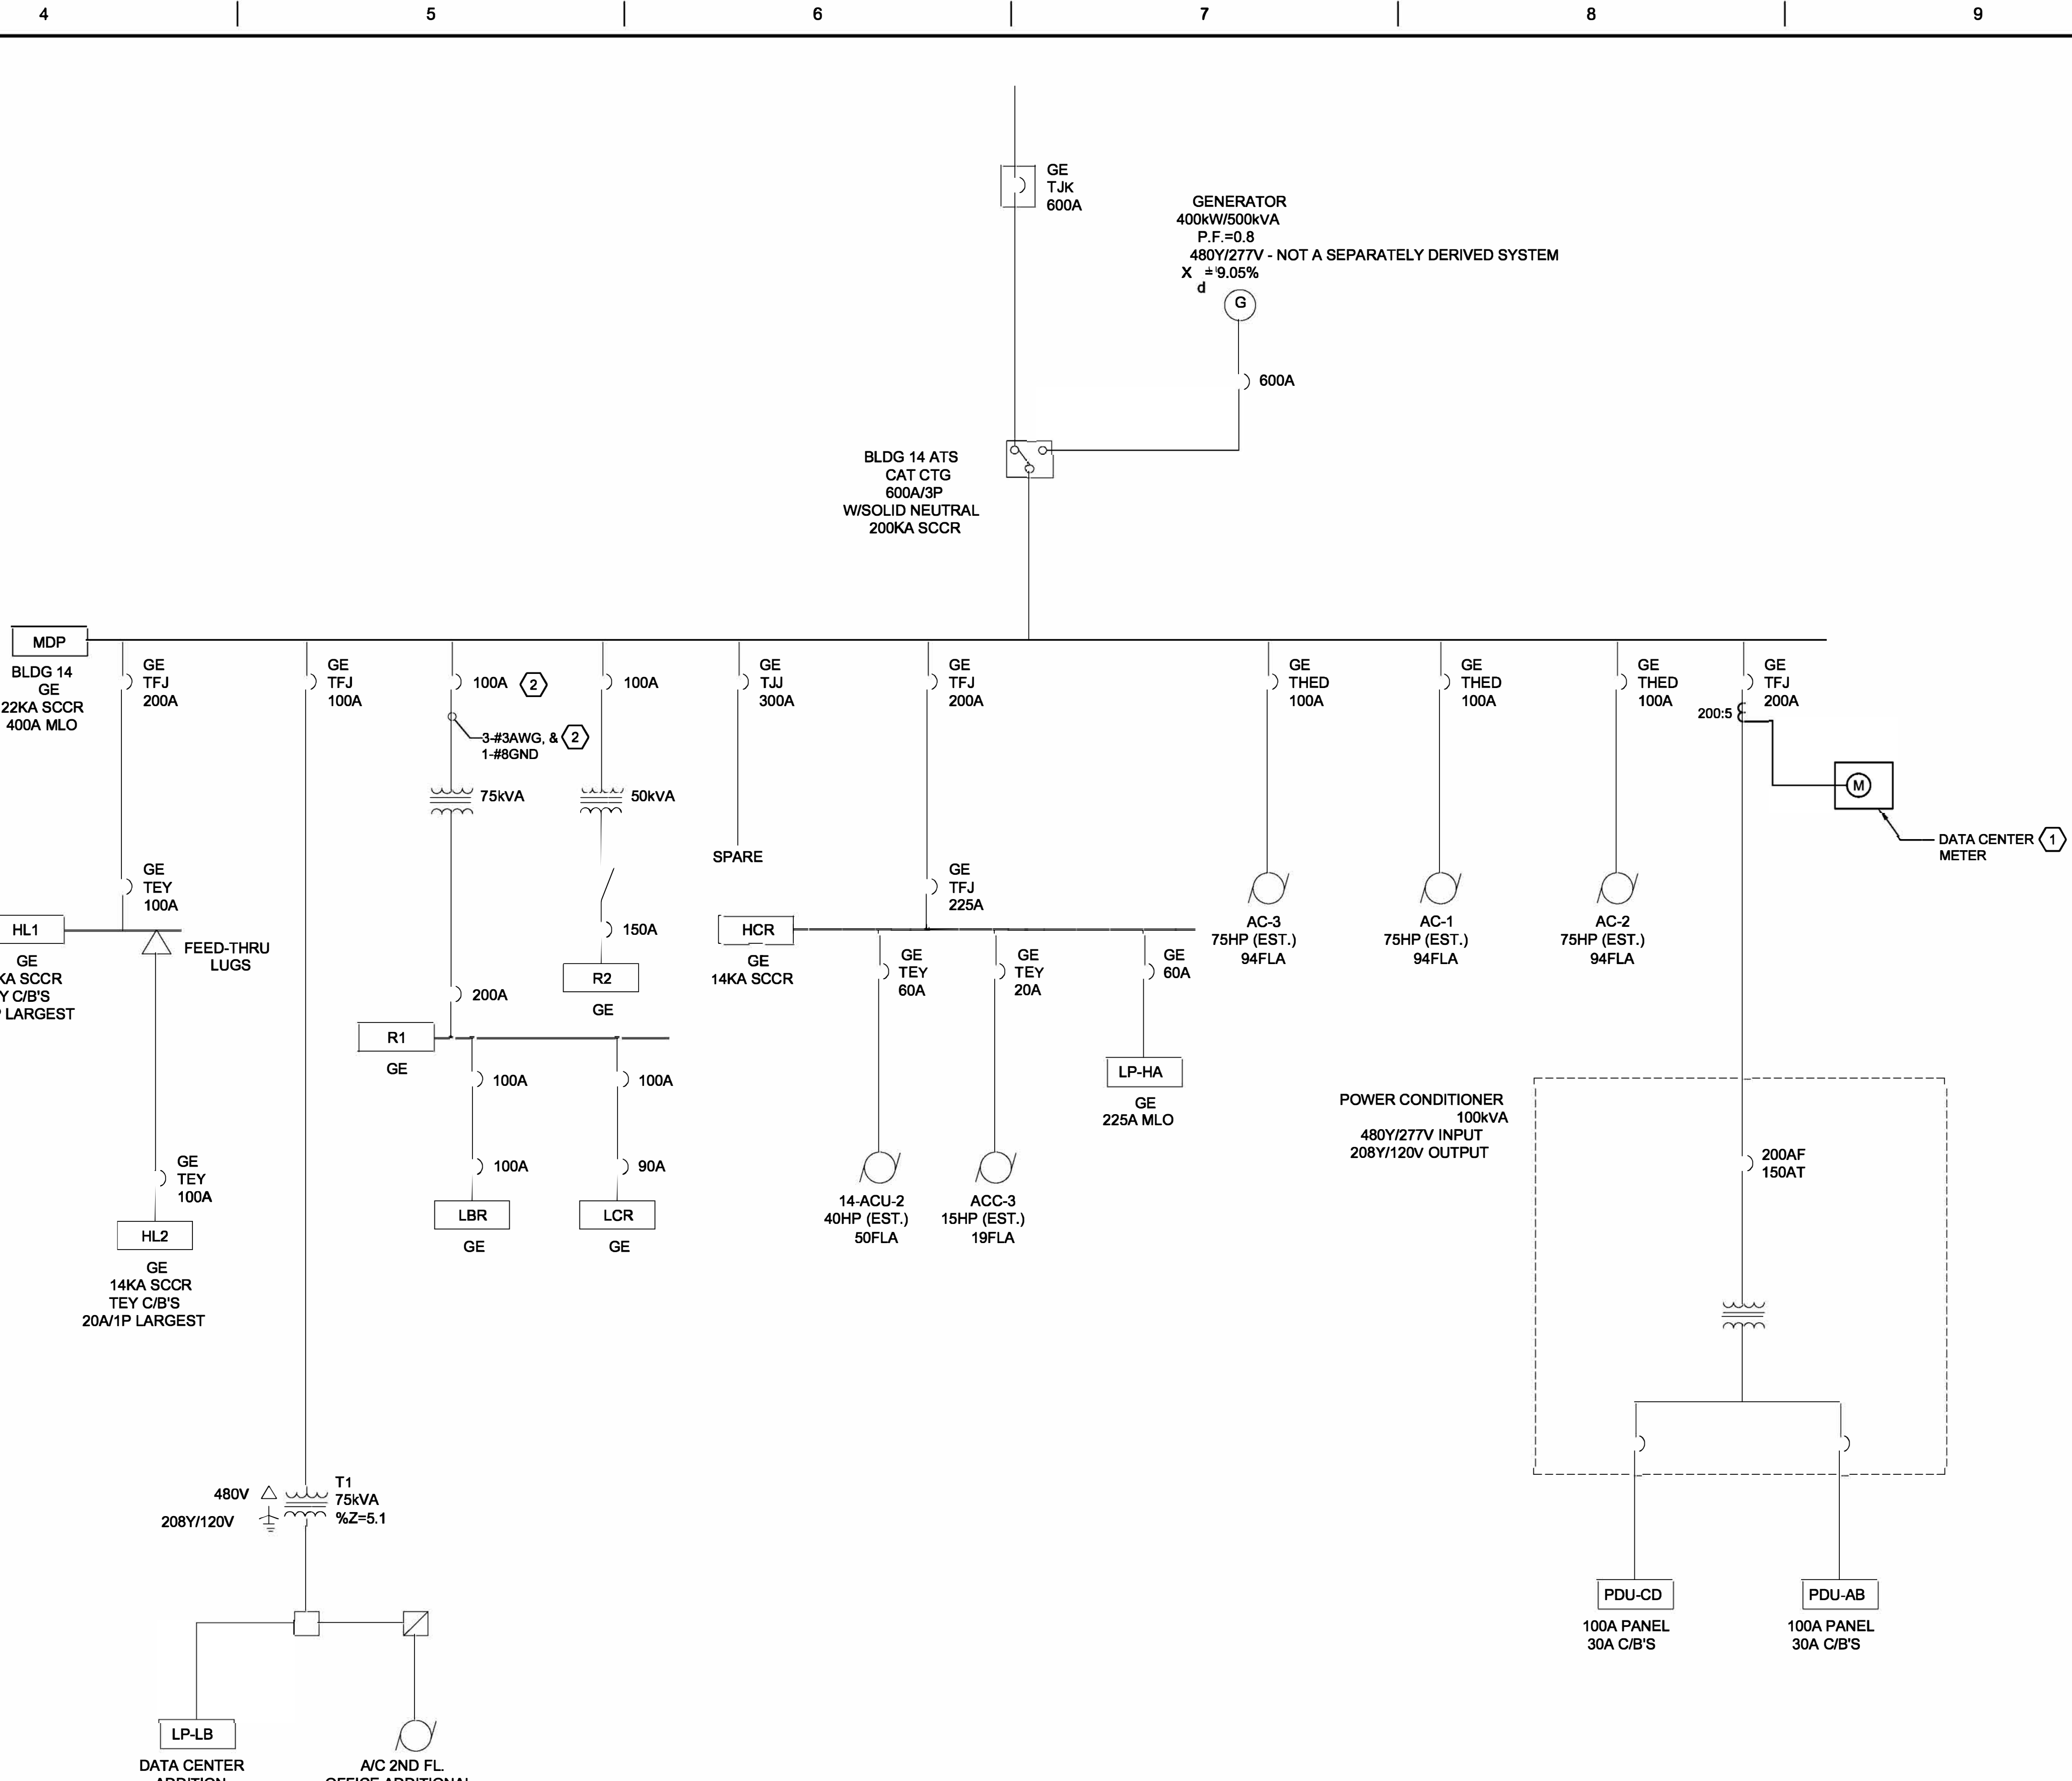


A4 PARTIAL BUILDING 14 ONE-LINE DIAGRAM - DATA CENTER METERING
NOT TO SCALE

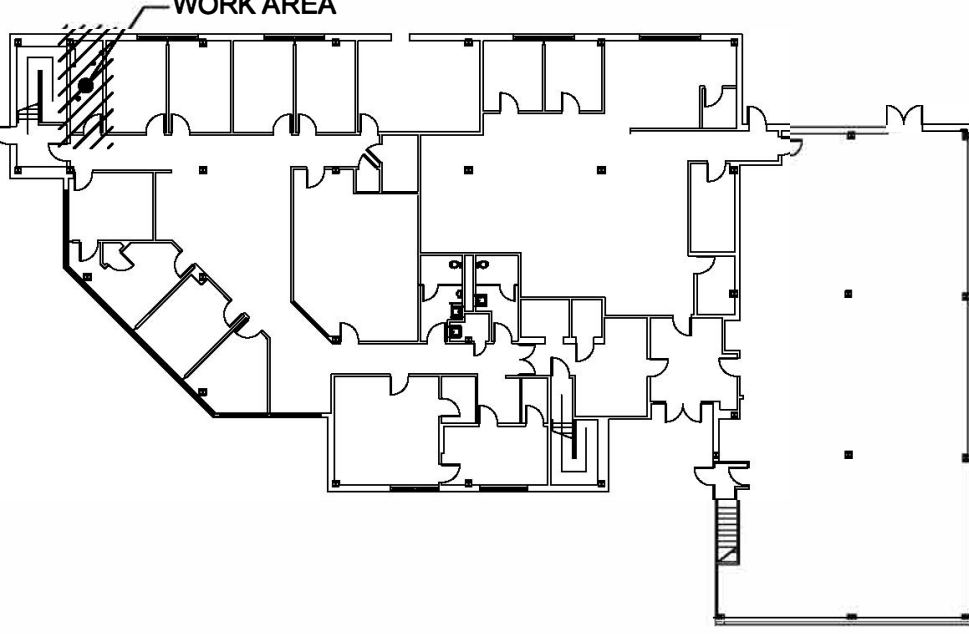

B14-KEY PLAN
NOT TO SCALE

CONSULTANTS: RAMBOLL RAMBOLL AMERICAS ENGINEERING SOLUTIONS, INC. 18 LINK DRIVE BINGHAMTON, NY 13902		STAMP 2022-08-17	ARCHITECT/ENGINEERS: 259 St. Ives Dr. Talent, OR 97540	APPROVED BY: VJC	DATE: 08/24/22	Drawing Title TASK ORDER 26 BUILDING 14 PARTIAL FIRST FLOOR PLAN AND ONE-LINE DIAGRAM Approved: Project Director	Project Title UPGRADE LIFE SAFETY/CRITICAL BRANCH ELECTRICAL DISTRIBUTION NY HARBOR HEALTHCARE CENTER VA BROOKLYN CAMPUS Location 800 POLY PLACE, BROOKLYN NY 11209	Project Number 630A4-16-430 Building Number 14 Drawing Number 18-01-BK EP-184 Dwg. 89 of 91	Office of Construction and Facilities Management
REV. 0 ISSUED FOR CONSTRUCTION Revisions:	Date 08/24/22								


three inches = one foot
one and one half inches = one foot
one inch = one foot
three quarters inch = one foot
one half inch = one foot
one quarter inch = one foot
one eighth inch = one foot
File Path: U:\DATA\SCC\25807261\UPGRADE ELECTRICAL\DWGS\18-01-BK\DWG\18-01-BK-02.DWG PLOT DATE: 8/16/2022 2:19 PM

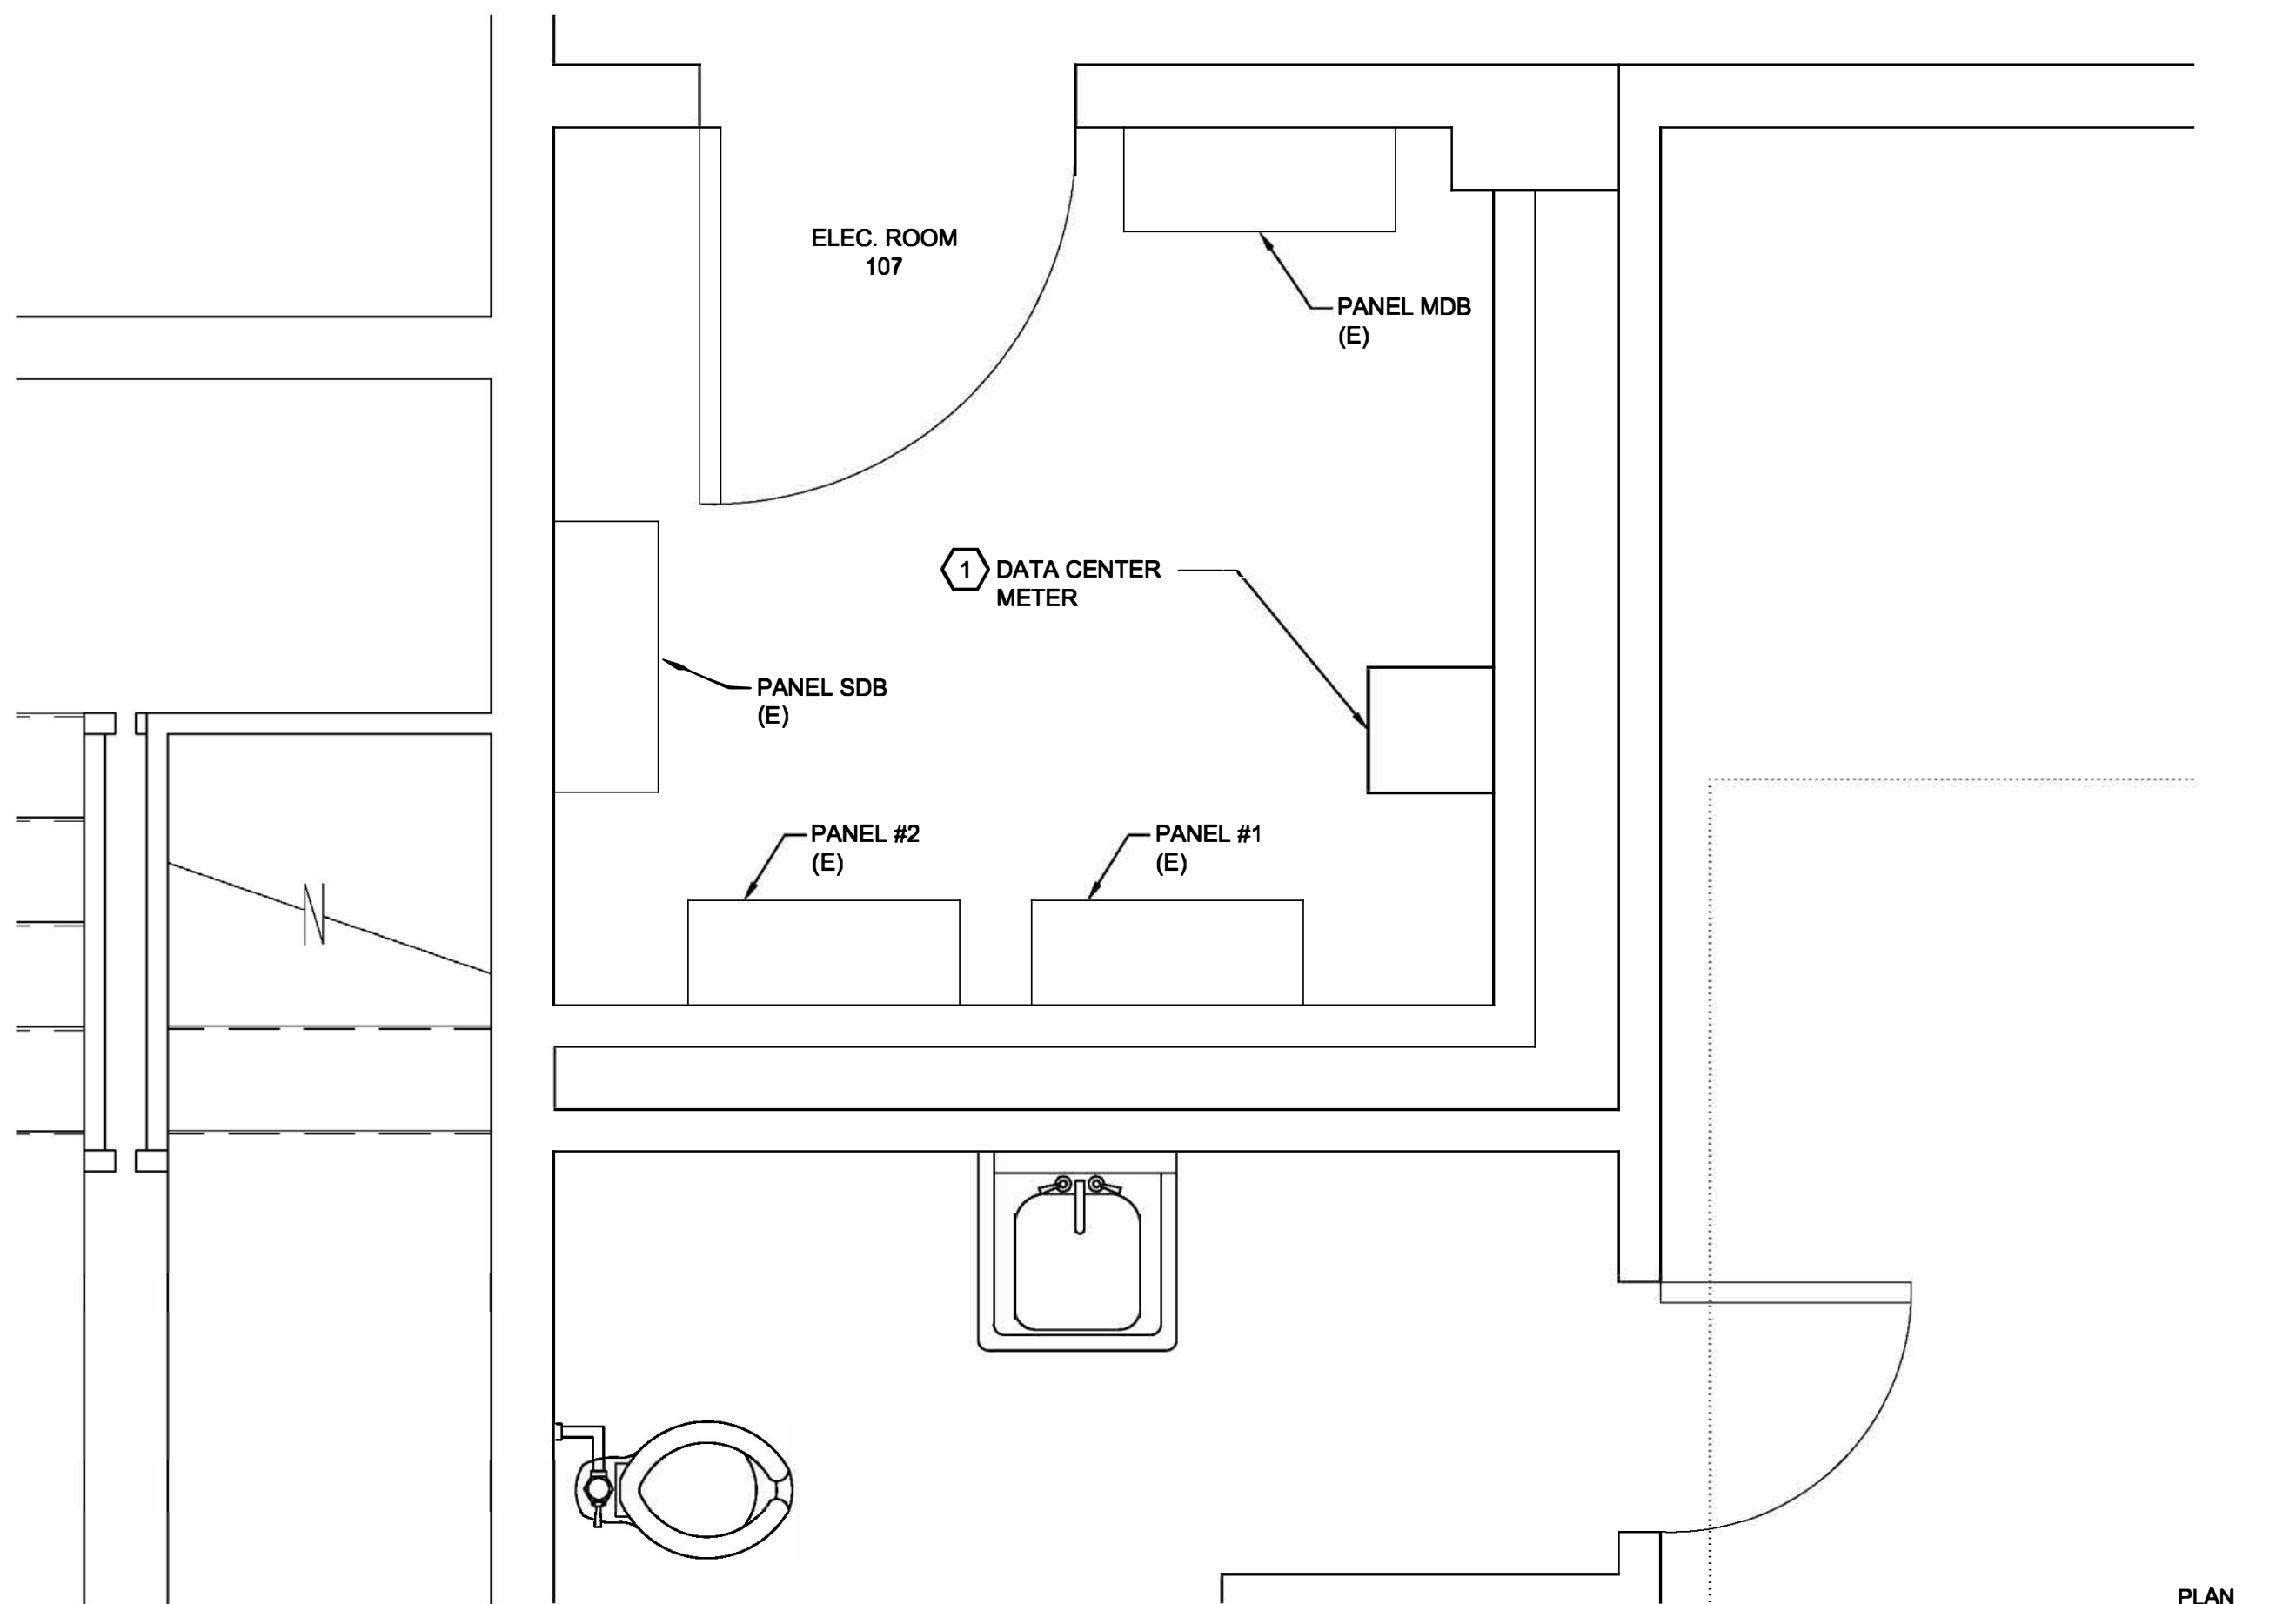


A1 PARTIAL BUILDING 2 FIRST FLOOR PLAN - DATA CENTER METERING

DRAWING NOTES:
1. WORK SHOWN THIS DRAWING SHALL TAKE PLACE ON NIGHT/WEEKEND SHIFTS.

INSTALLATION KEYNOTES: (#)
1. PROVIDE ALL MATERIAL AND LABOR TO DISCONNECT AND REMOVE EXISTING DATA CENTER METER. PROVIDE METER FOR DATACENTER FEEDER FROM BUILDING 2. FEEDER METER SHALL BE SQUARE D POWER LOGIC PM800 OR APPROVED EQUAL WITH ETHERNET COMMUNICATION CARD. PROVIDE REVENUE METERING GRADE CTs ON FEEDER CIRCUIT. PROVIDE CAT5E CABLE IN 3/4" TO DATA CONNECTION POINT. METER SHALL BE CONNECTED TO VA NATIONAL METERING SYSTEM.

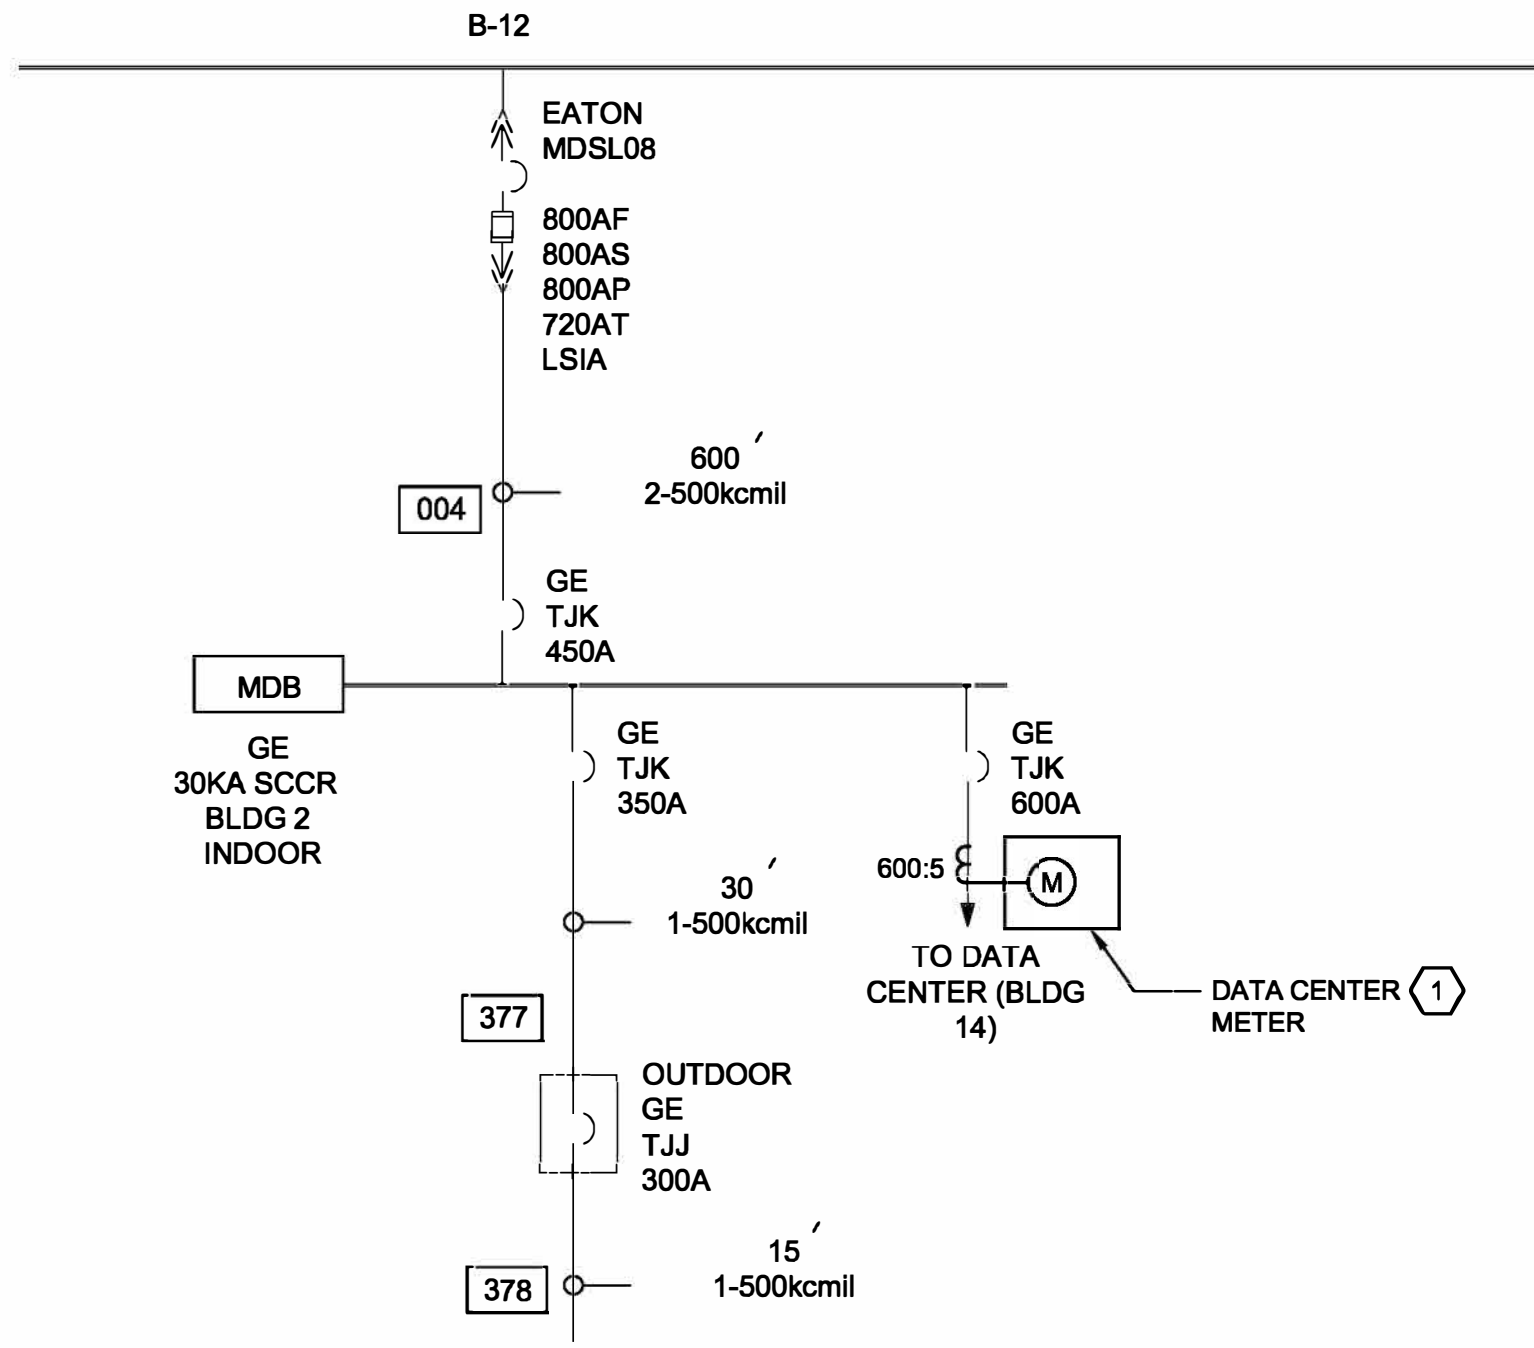

A6 PARTIAL BUILDING 2 ONE-LINE DIAGRAM - DATA CENTER METERING

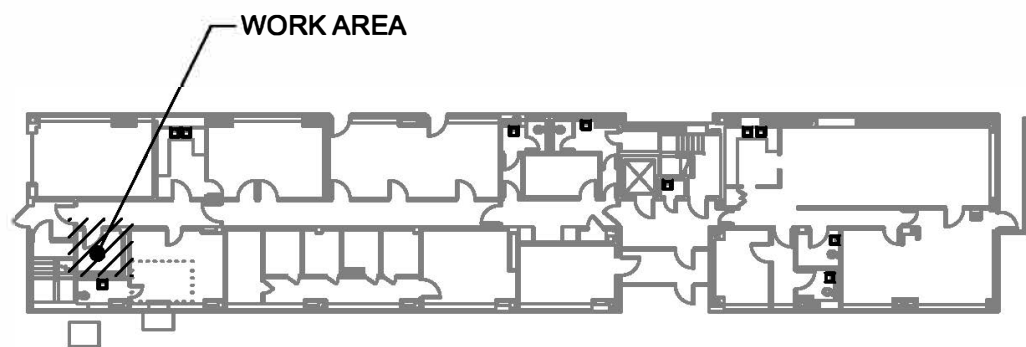

B2 - KEY PLAN

CONSULTANTS: RAMBOLL RAMBOLL AMERICAS ENGINEERING SOLUTIONS, INC. 18 LINK DRIVE BINGHAMTON, NY 13902		STAMP 2022-08-17	ARCHITECT/ENGINEERS: 259 St. Ives Dr. Talent, OR 97540	APPROVED BY: VJC DATE: 08/24/22	Drawing Title TASK ORDER 26 BUILDING 2 PARTIAL FIRST FLOOR PLAN AND ONE-LINE DIAGRAM Approved: Project Director	Project Title UPGRADE LIFE SAFETY/CRITICAL BRANCH ELECTRICAL DISTRIBUTION NY HARBOR HEALTHCARE CENTER VA BROOKLYN CAMPUS Location 800 POLY PLACE, BROOKLYN NY 11209	Project Number 630A4-16-430 Building Number 2 Drawing Number 18-01-BK EP-185 Dwg. 90 of 91	Office of Construction and Facilities Management
REV. 0 ISSUED FOR CONSTRUCTION Revisions:		Issue Date 08/24/22 Checked BKD Drawn KMB						

